


Proposed 2 Story Addition

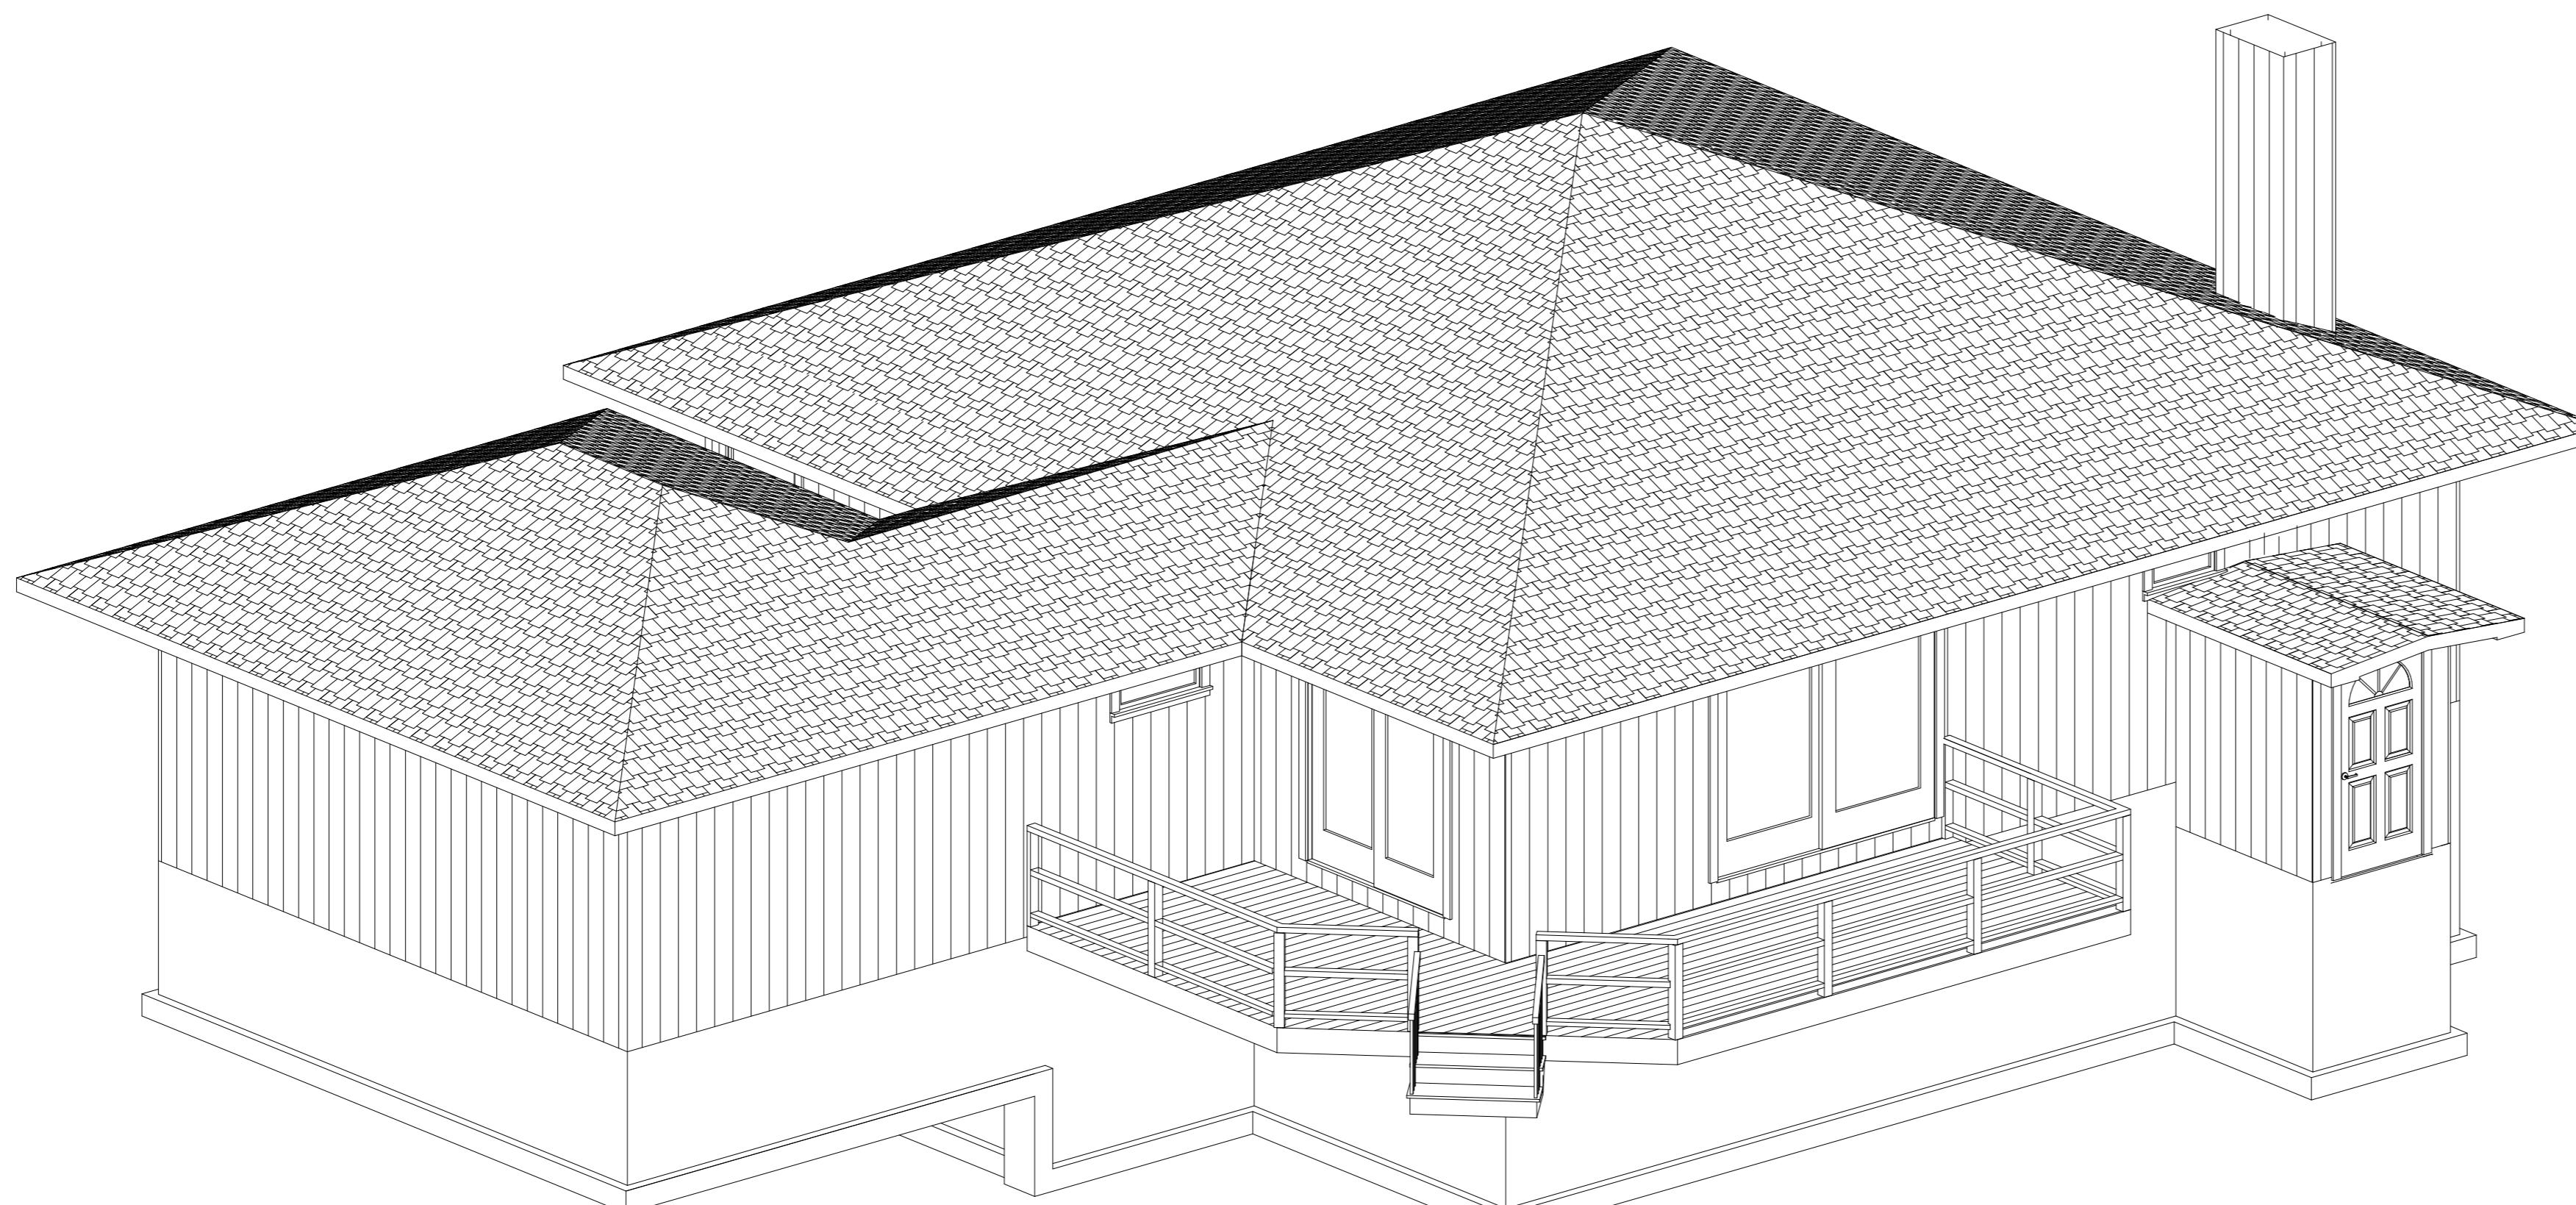

Existing Home

#### Contents:

- 1 Overview
- 2 Perspectives
- 3 Foundation Plan
- 4 First Floor Plan & Existing Plan
- 5 Second Floor Plan & Specifications
- 6 Elevations
- 7 Elevations
- 8 Roof Plans
- 9 First Floor Framing Plans
- 10 Second Floor Framing and Ceiling Plans
- 11 Roof Framing Plans
- 12 Sections
- 13 Electrical Plan

Ada & David Kohlus  
Residence  
Montauk, NY

Revision 2.1

Copyright (c) 2003. All rights reserved.  
**David A. Webb, Inc.**  
Design, Drafting, Engineering,  
General Contracting  
516 - 982 - 8502


Overview	Date	Drawn by	Scale	Sheet
	3/5/03	DW	1/8" = 1'	1




From North



From East

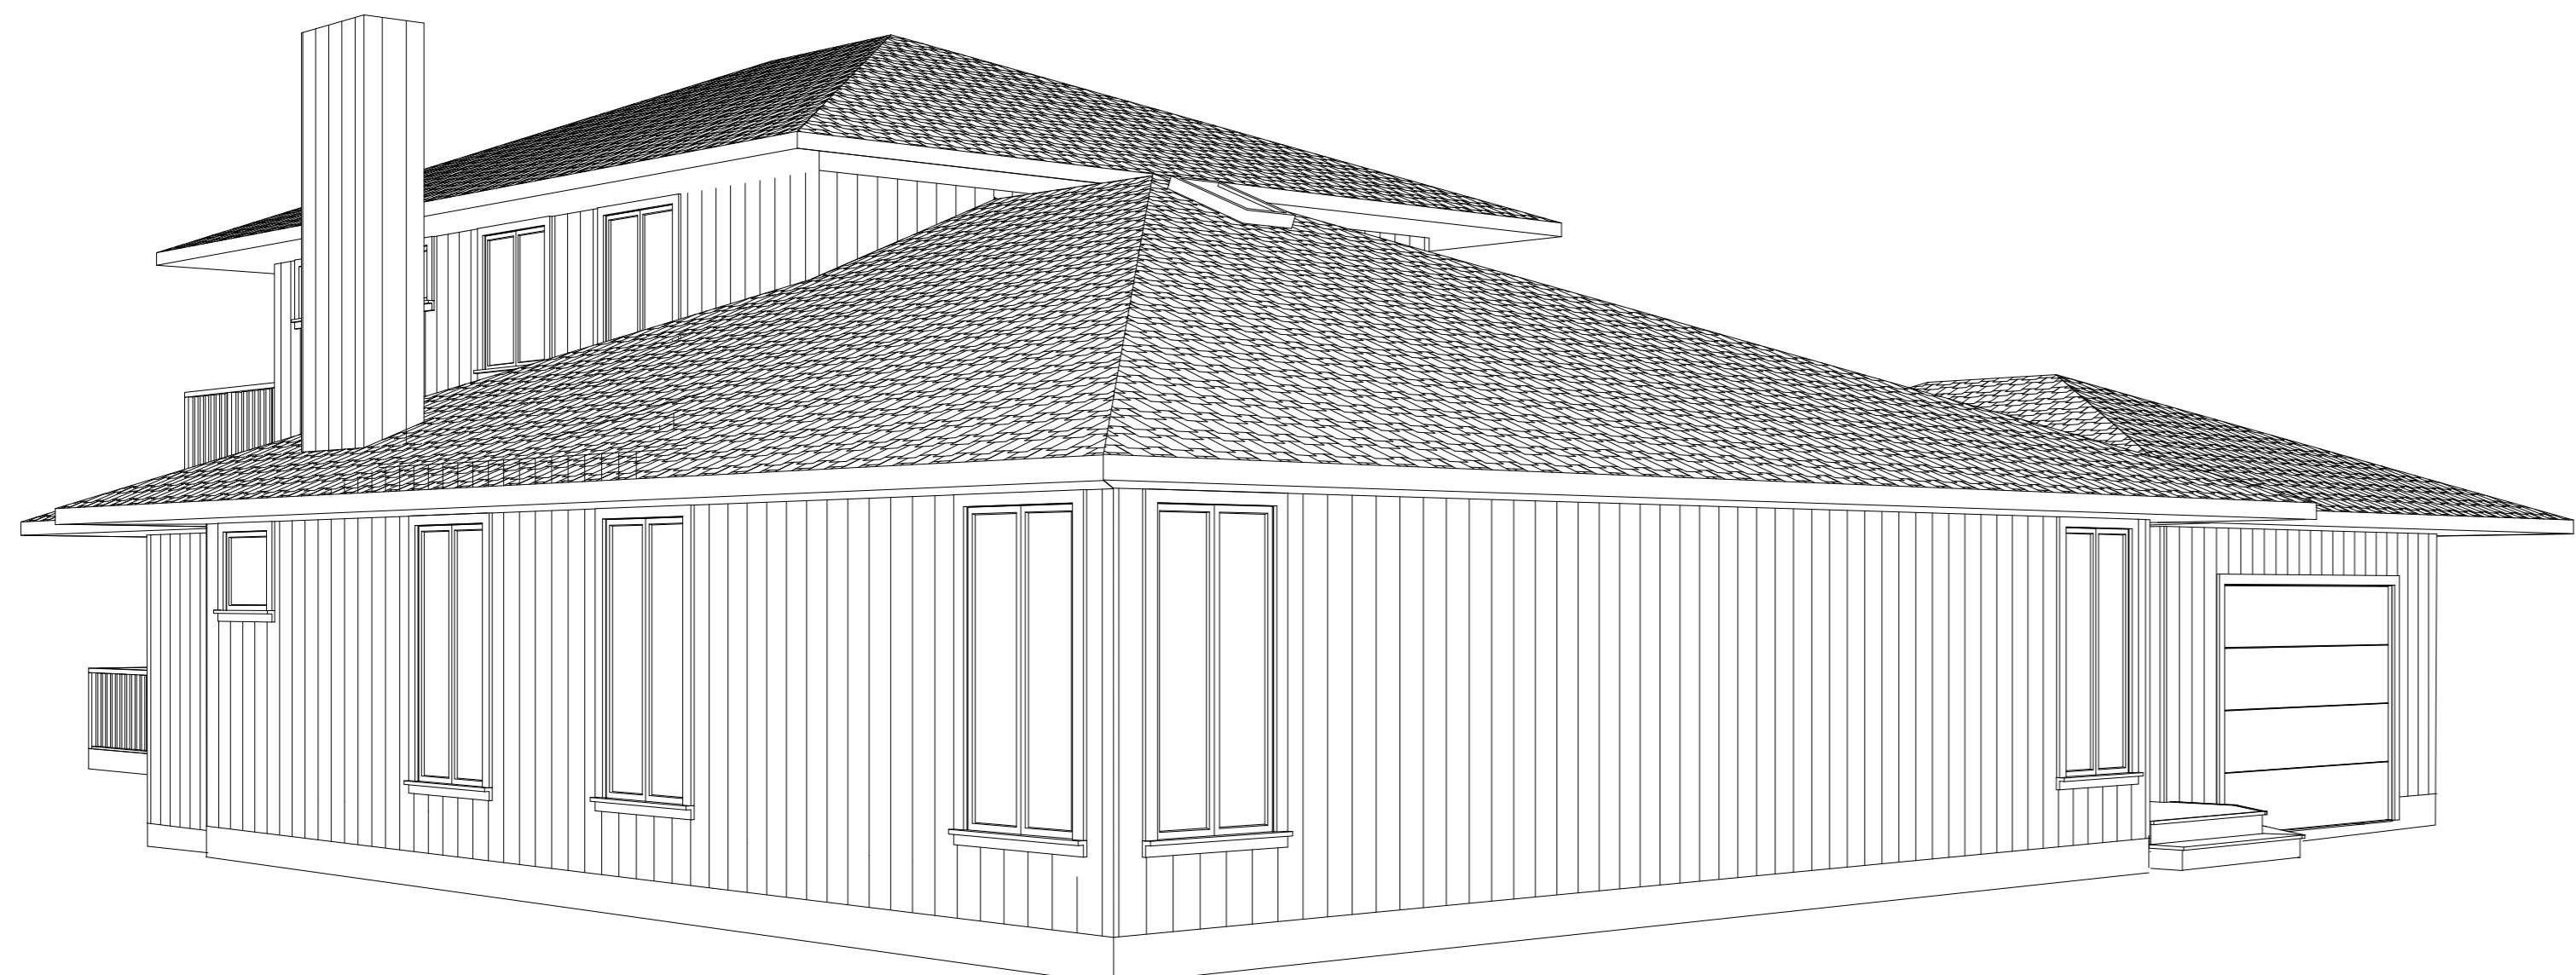

From South

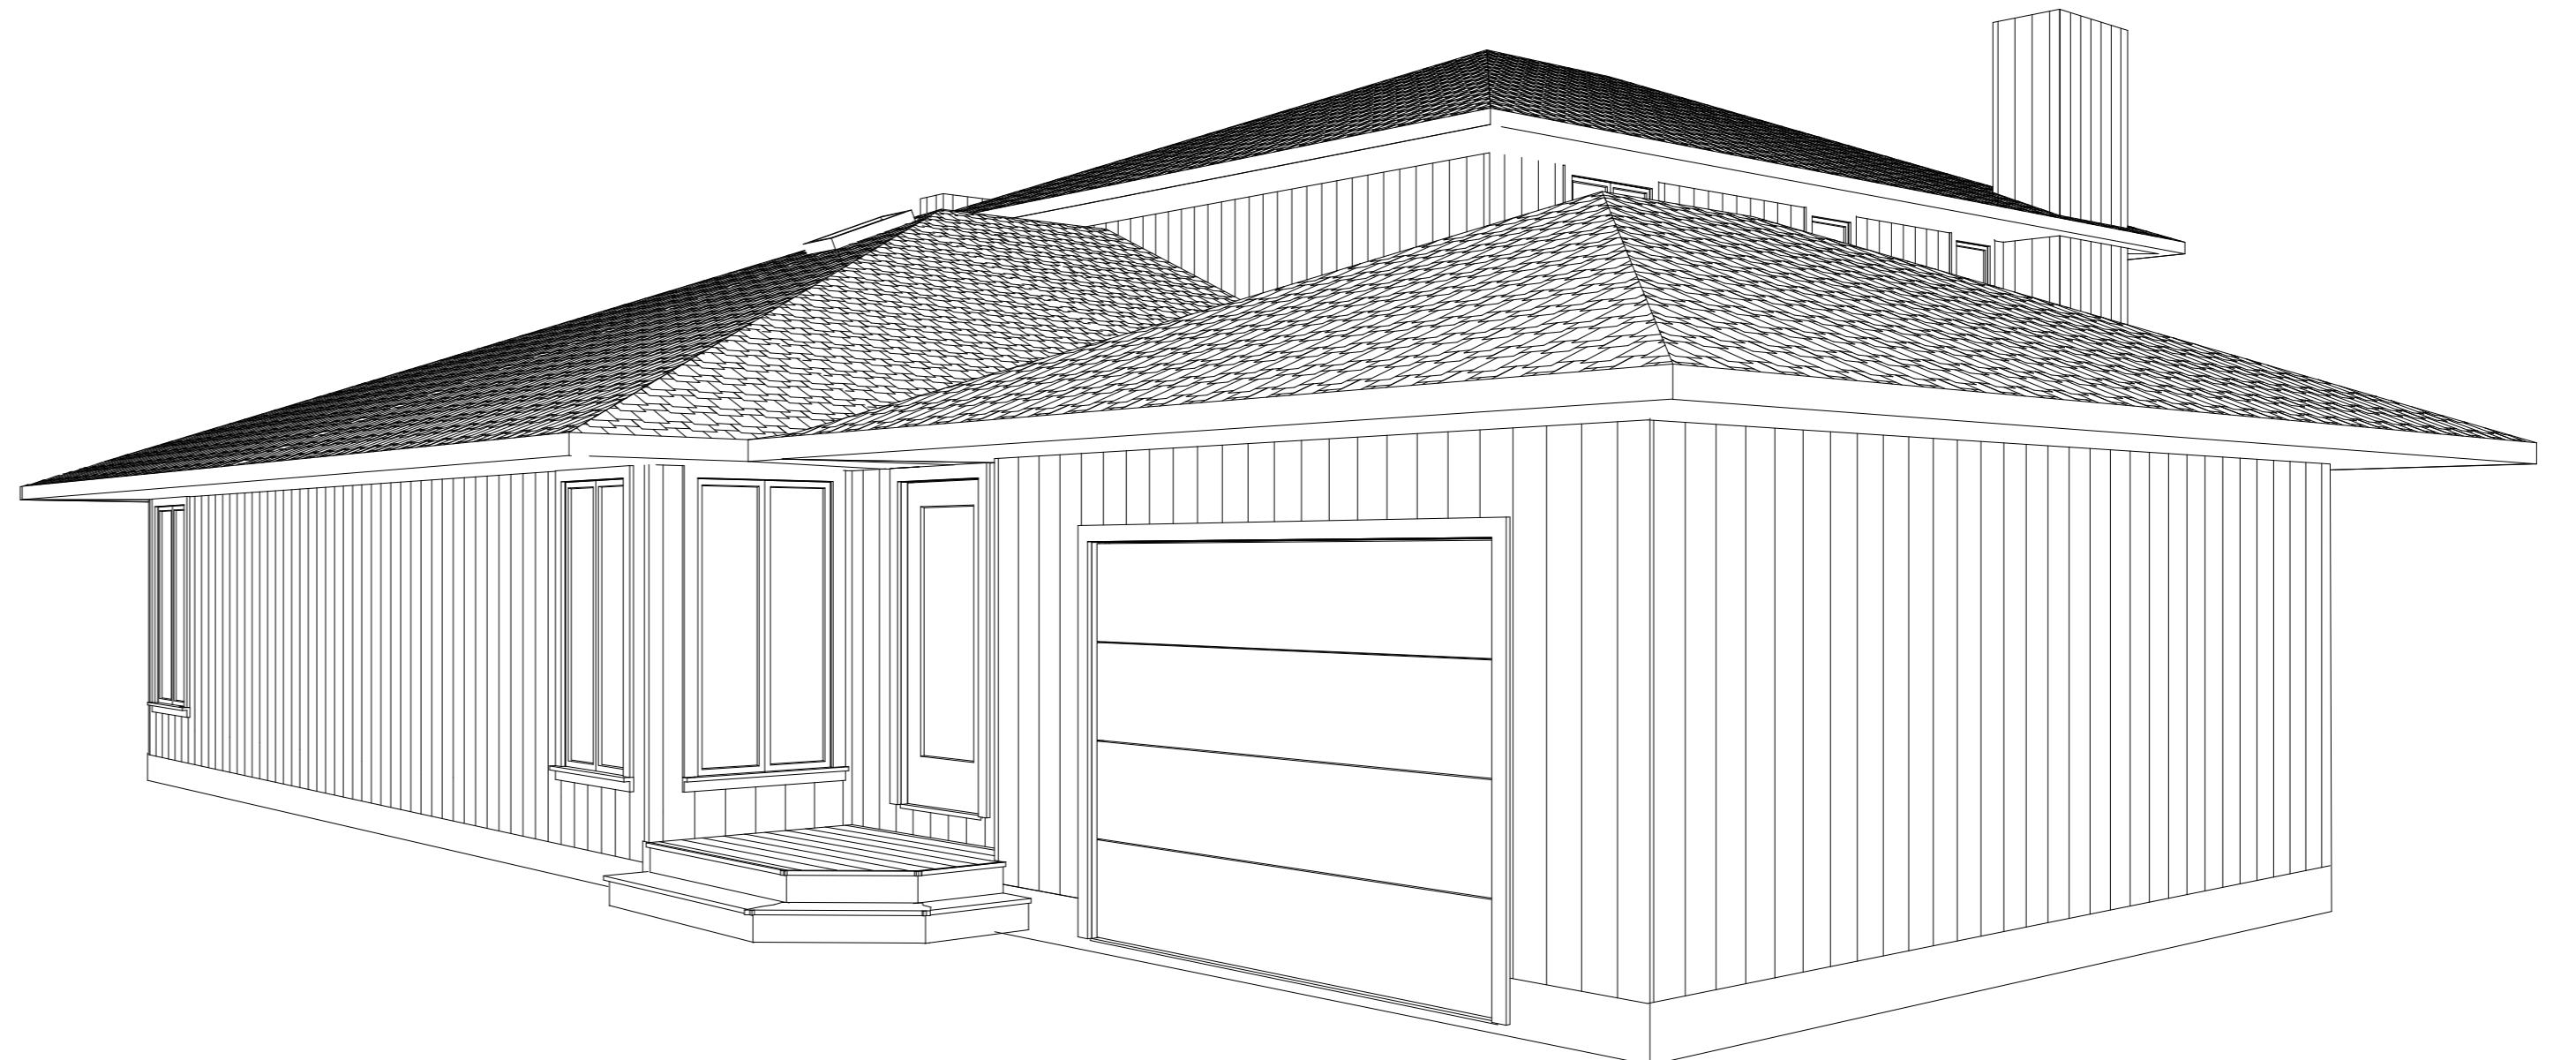

From West



Ada & David Kohlus  
Residence  
Montauk, NY

Revision 2.1

Copyright (c) 2003. All rights reserved.  
**David A. Webb, Inc.**  
Design, Drafting, Engineering,  
General Contracting  
516 - 982 - 8502

Ground-Level Perspectives

Date	Drawn by	Scale	Sheet
3/5/03	DW	1/8" = 1'	2

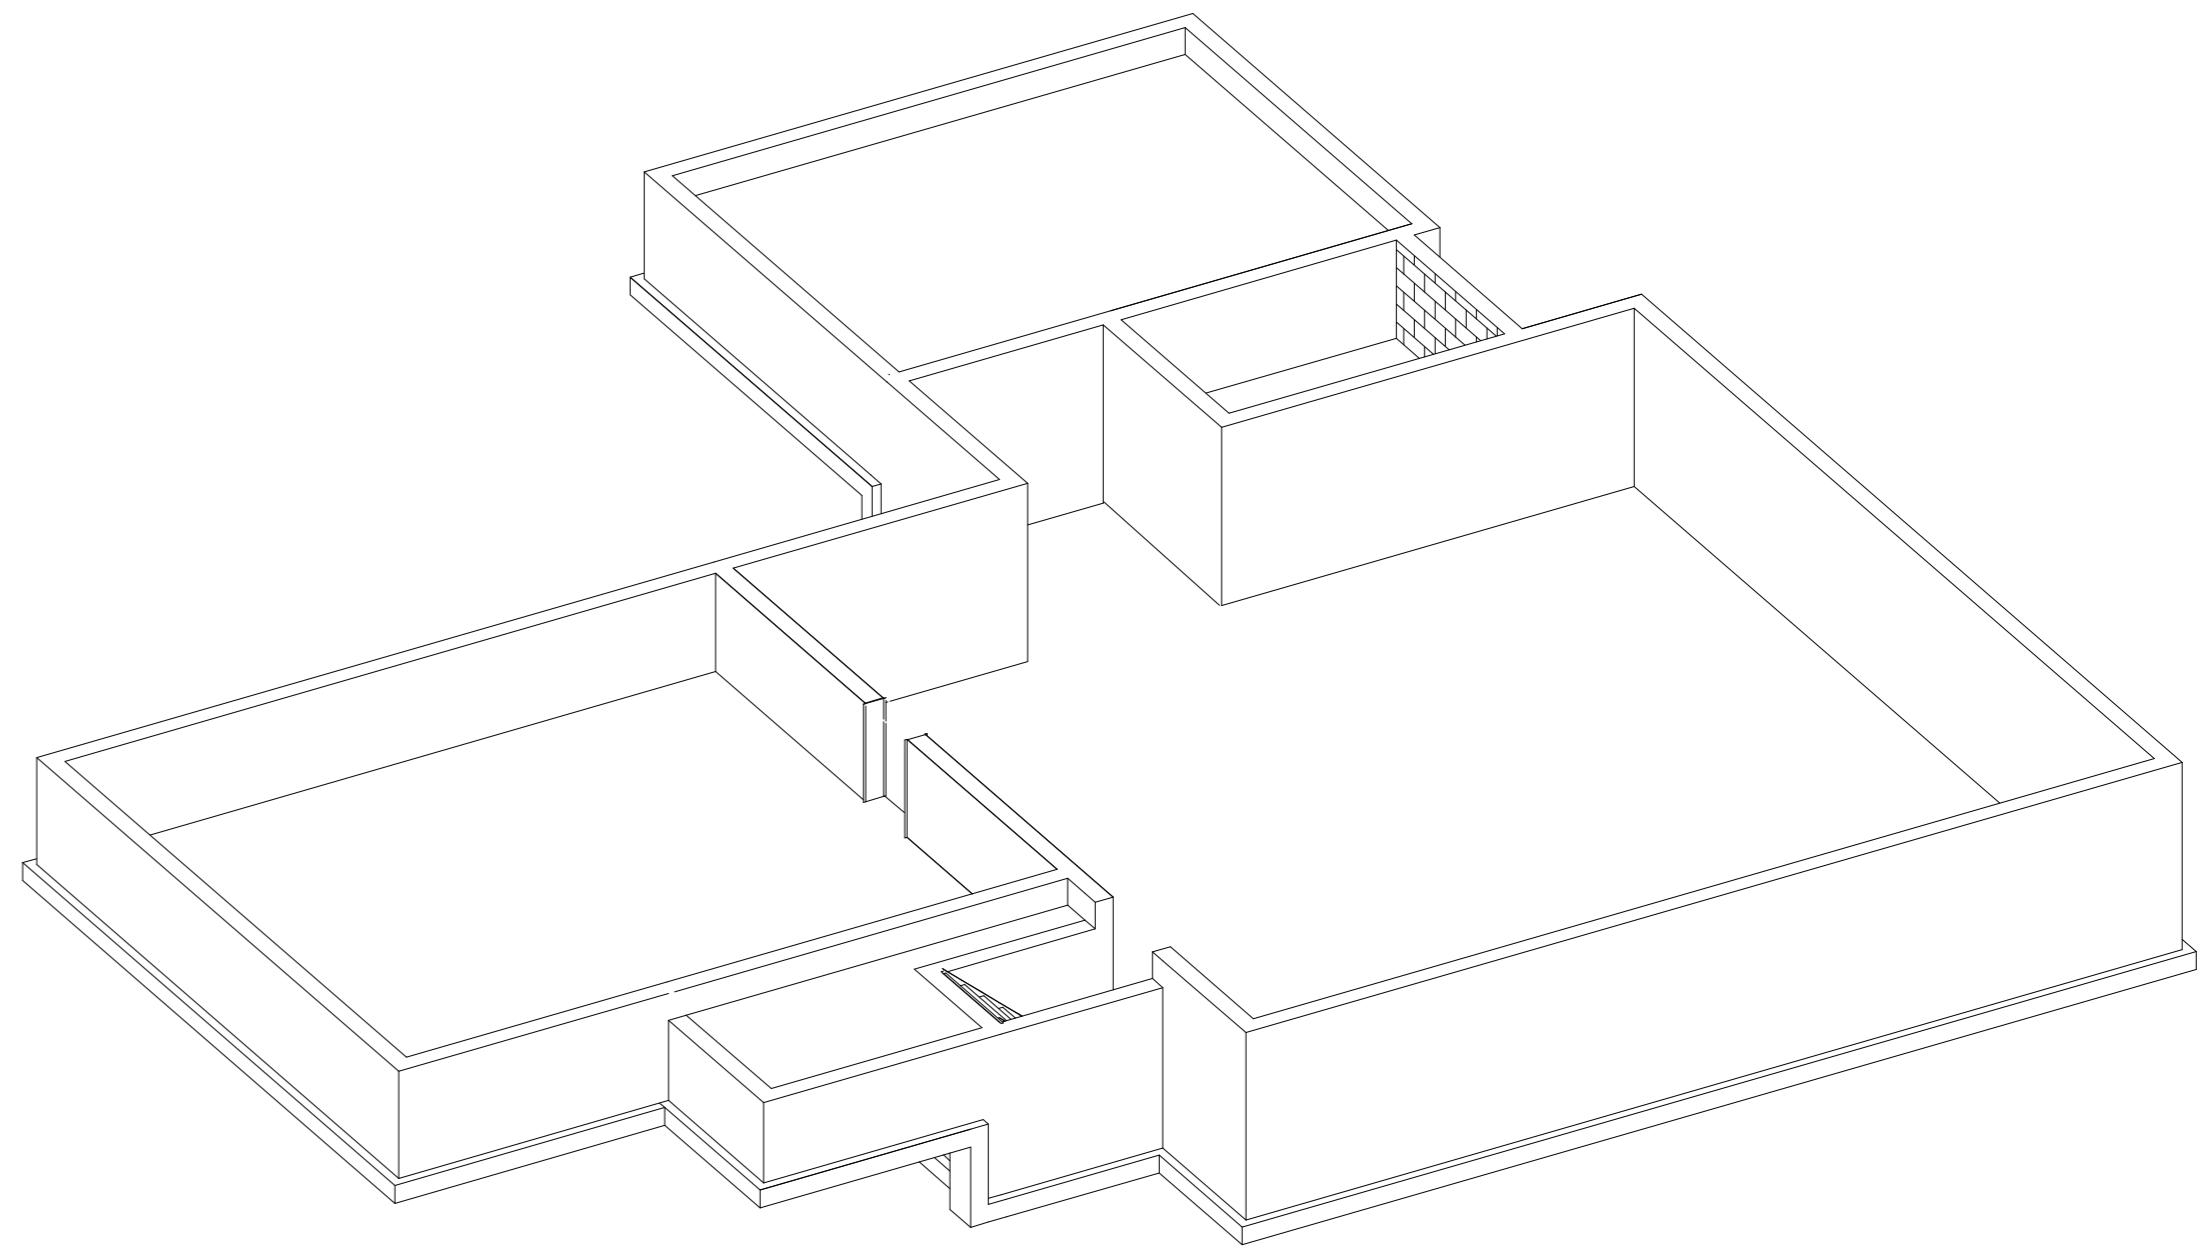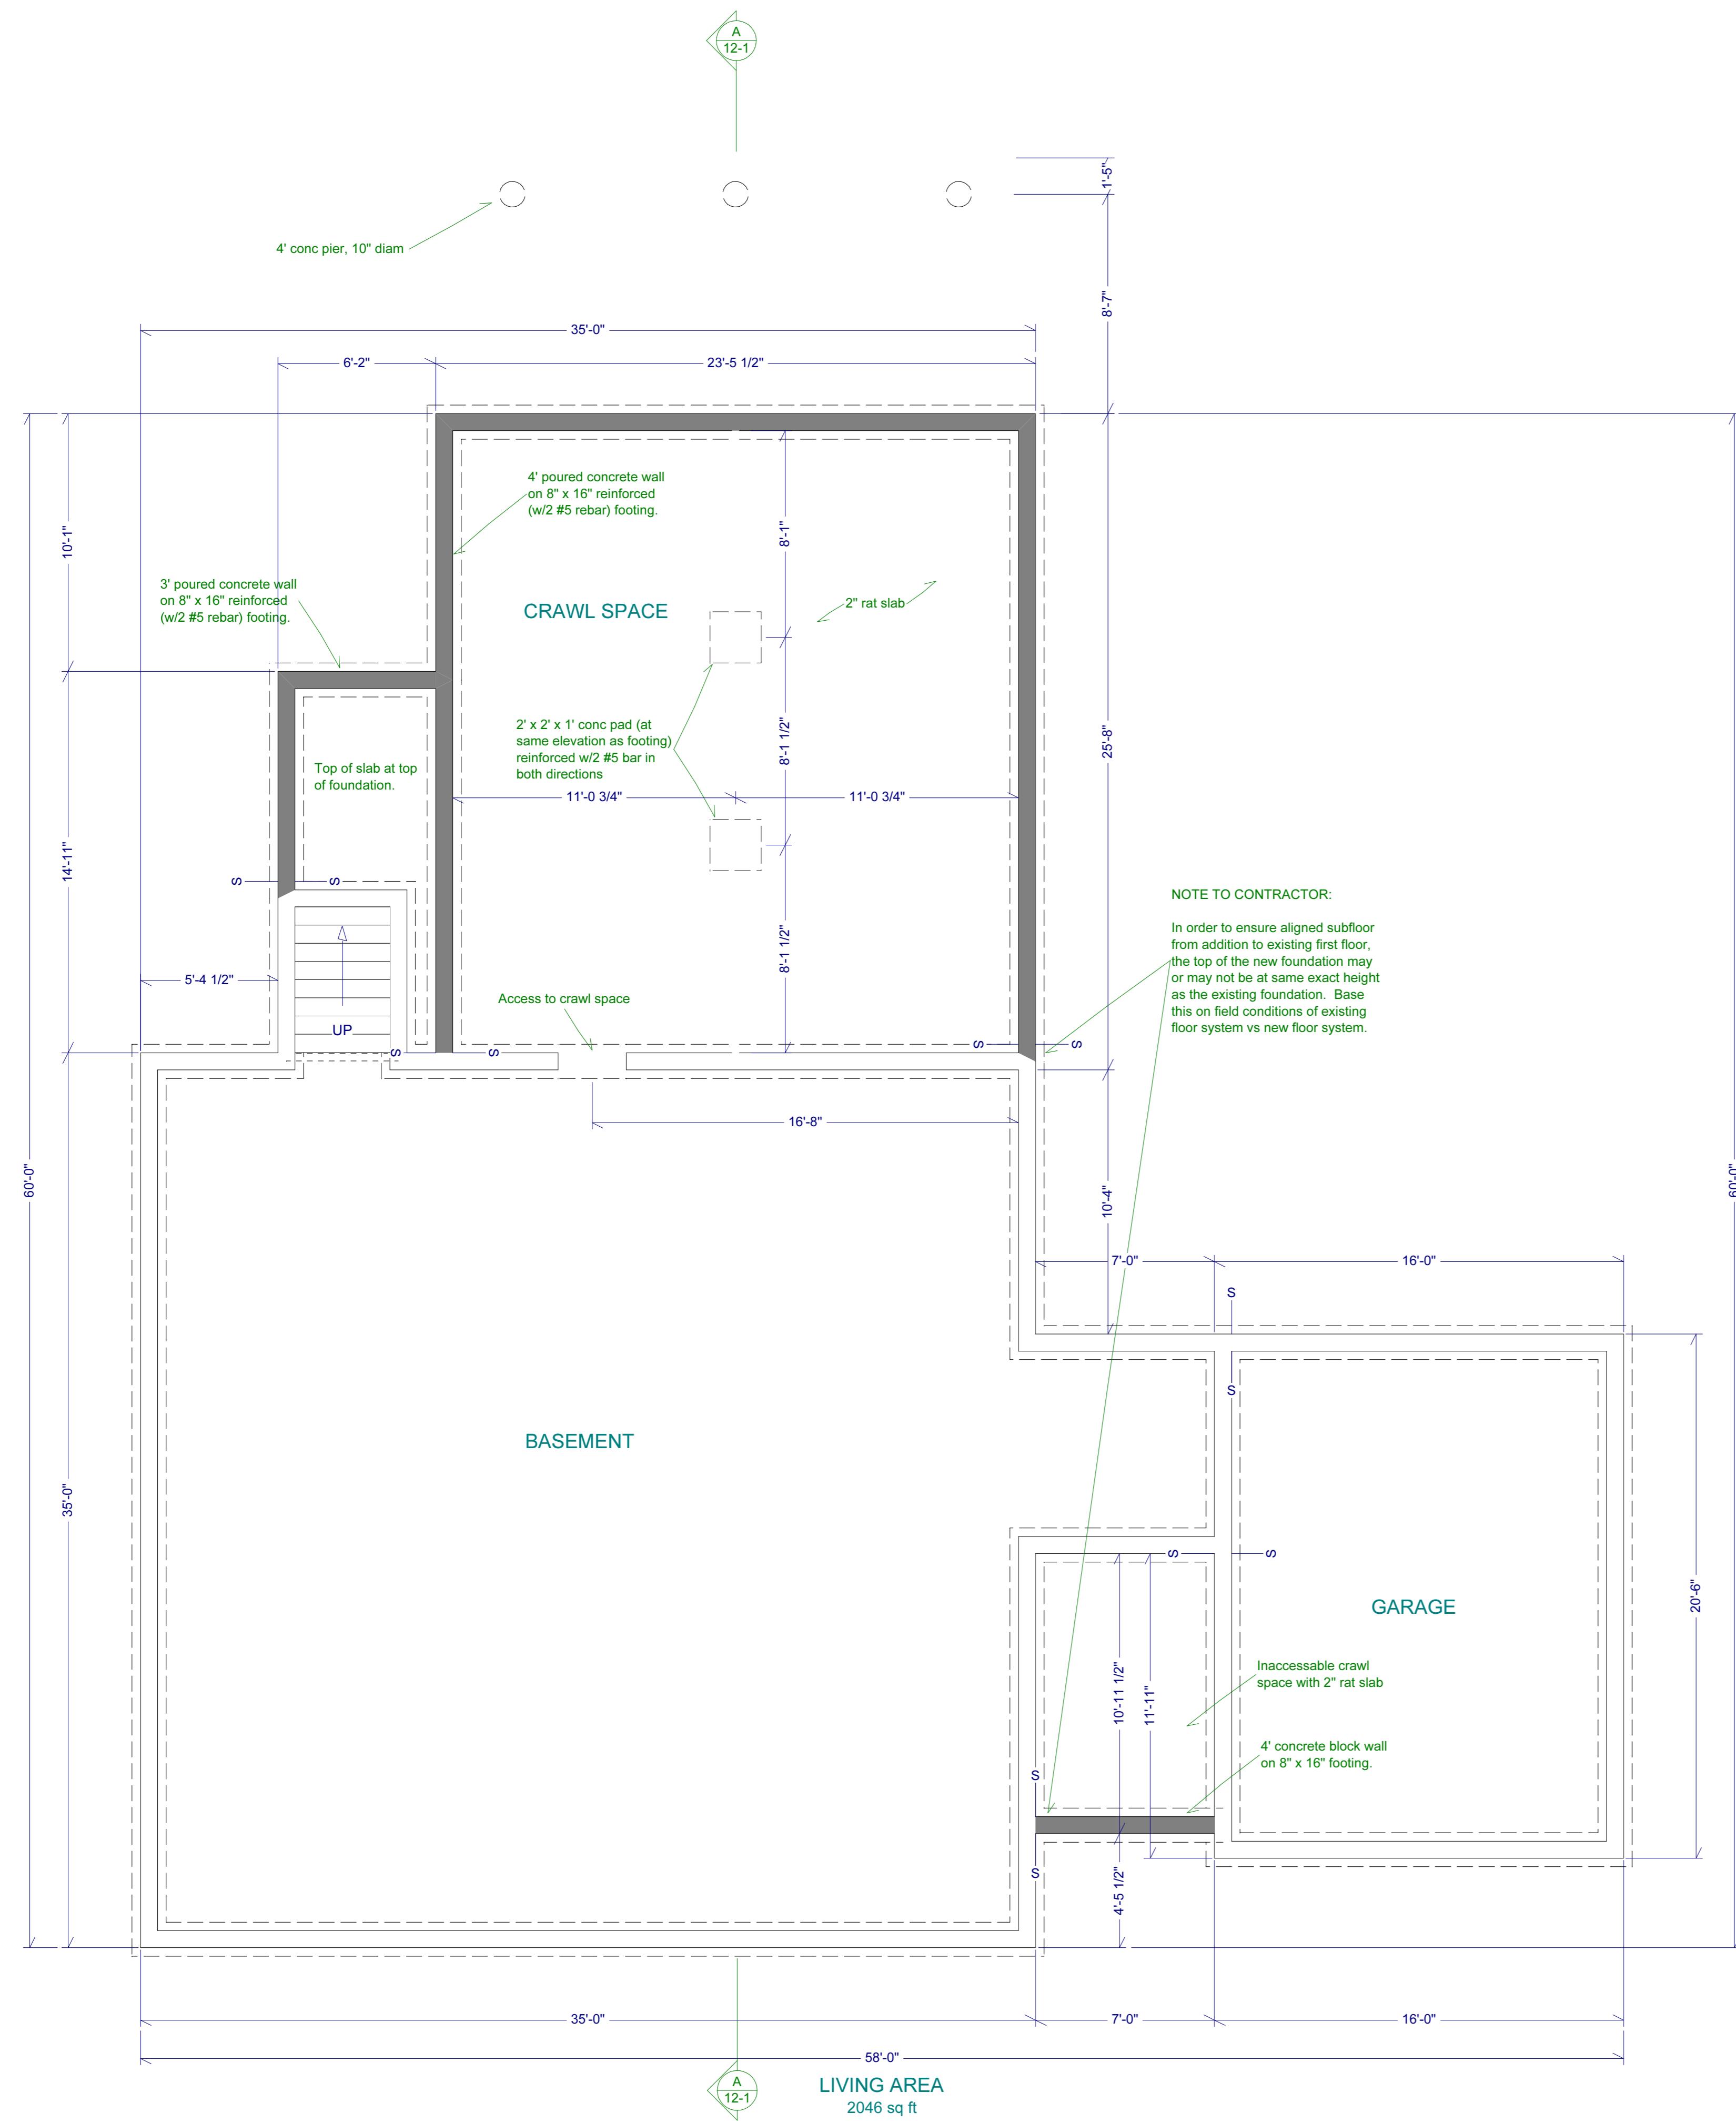

Foundation Overview - From North



Ada & David Kohlus  
Residence  
Montauk, NY

Foundation Plan

Revision 2.1

Copyright (c) 2003. All rights reserved.  
**David A. Webb, Inc.**  
Design, Drafting, Engineering,  
General Contracting  
516 - 982 - 8502

Date	Drawn by	Scale	Sheet
3/5/03	DW	1/8" = 1'	3

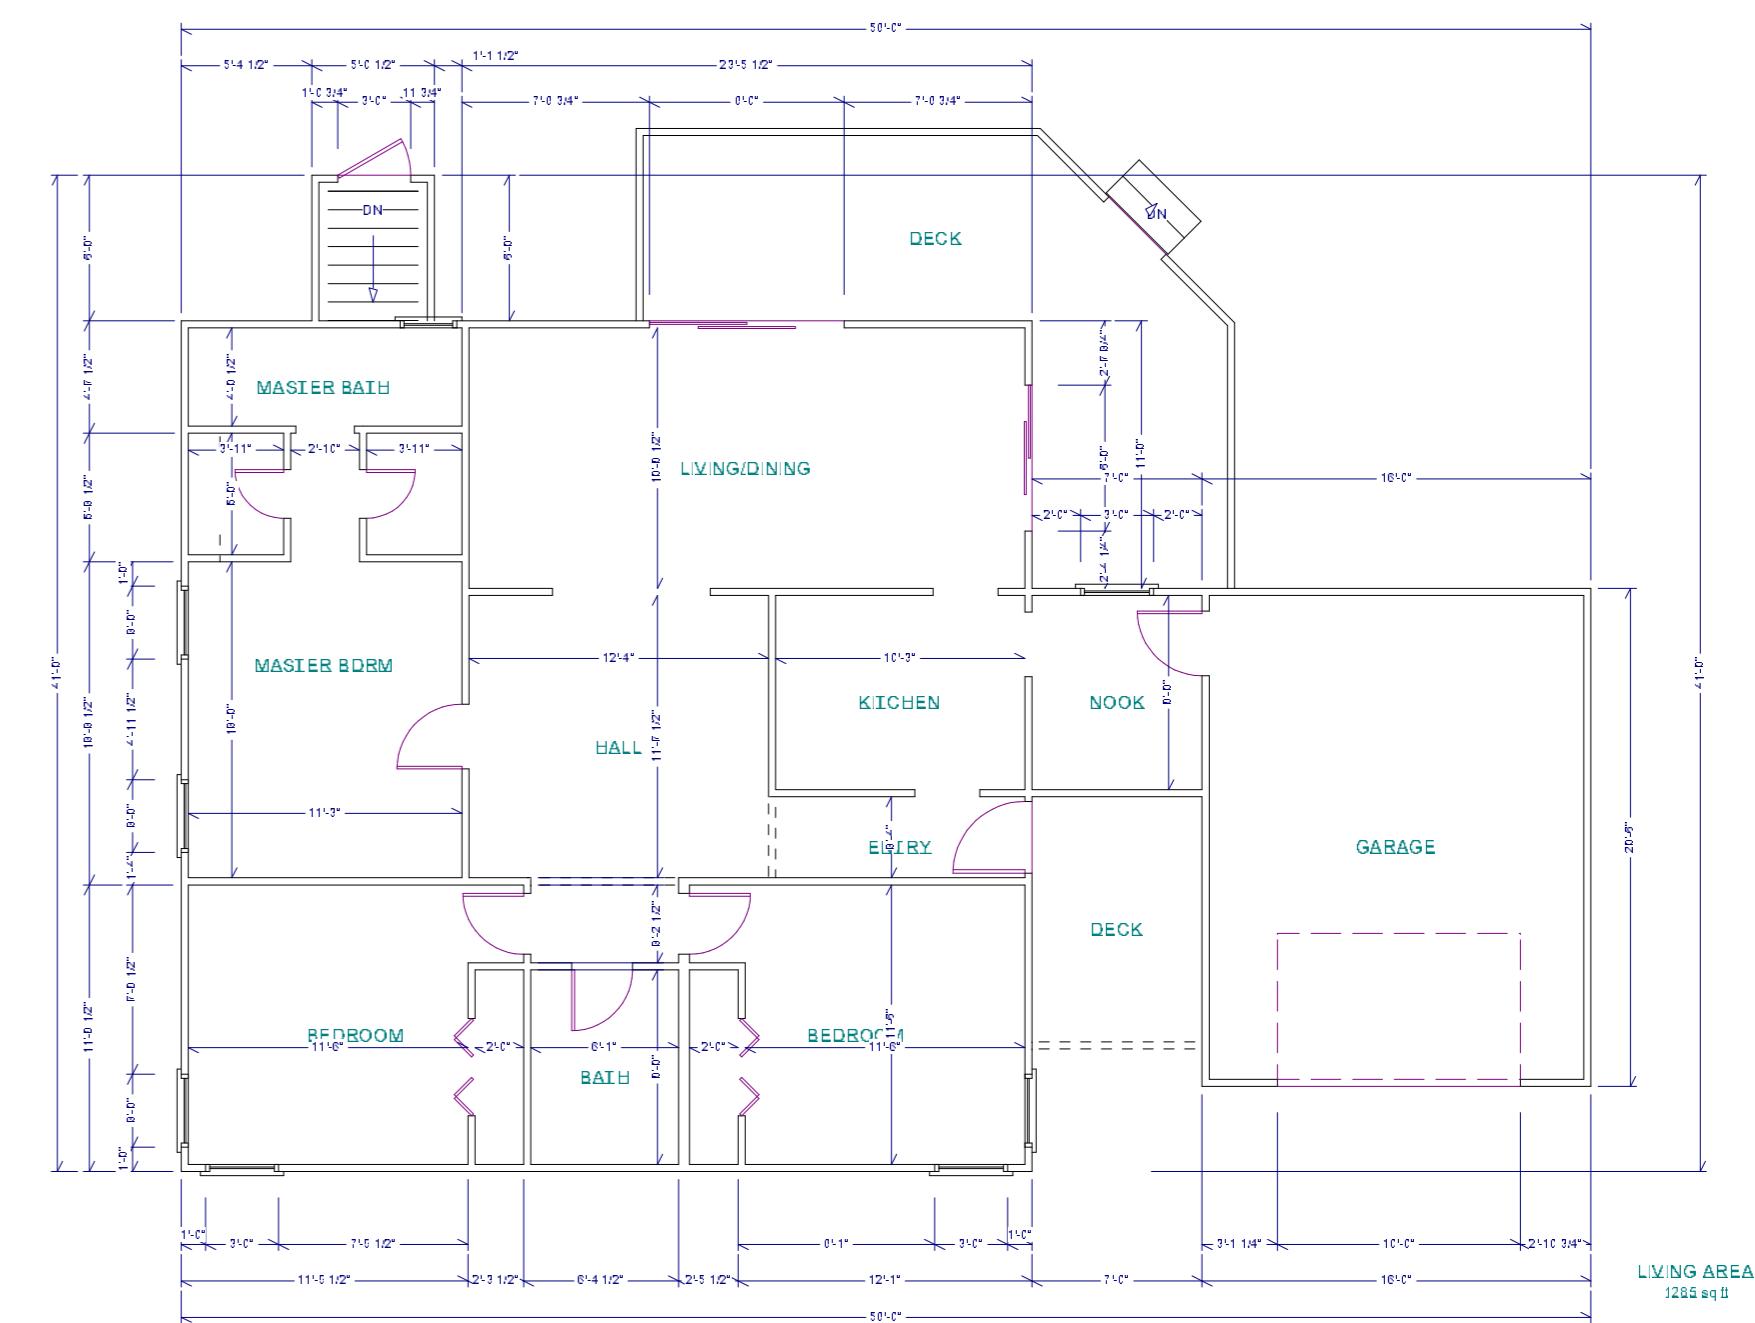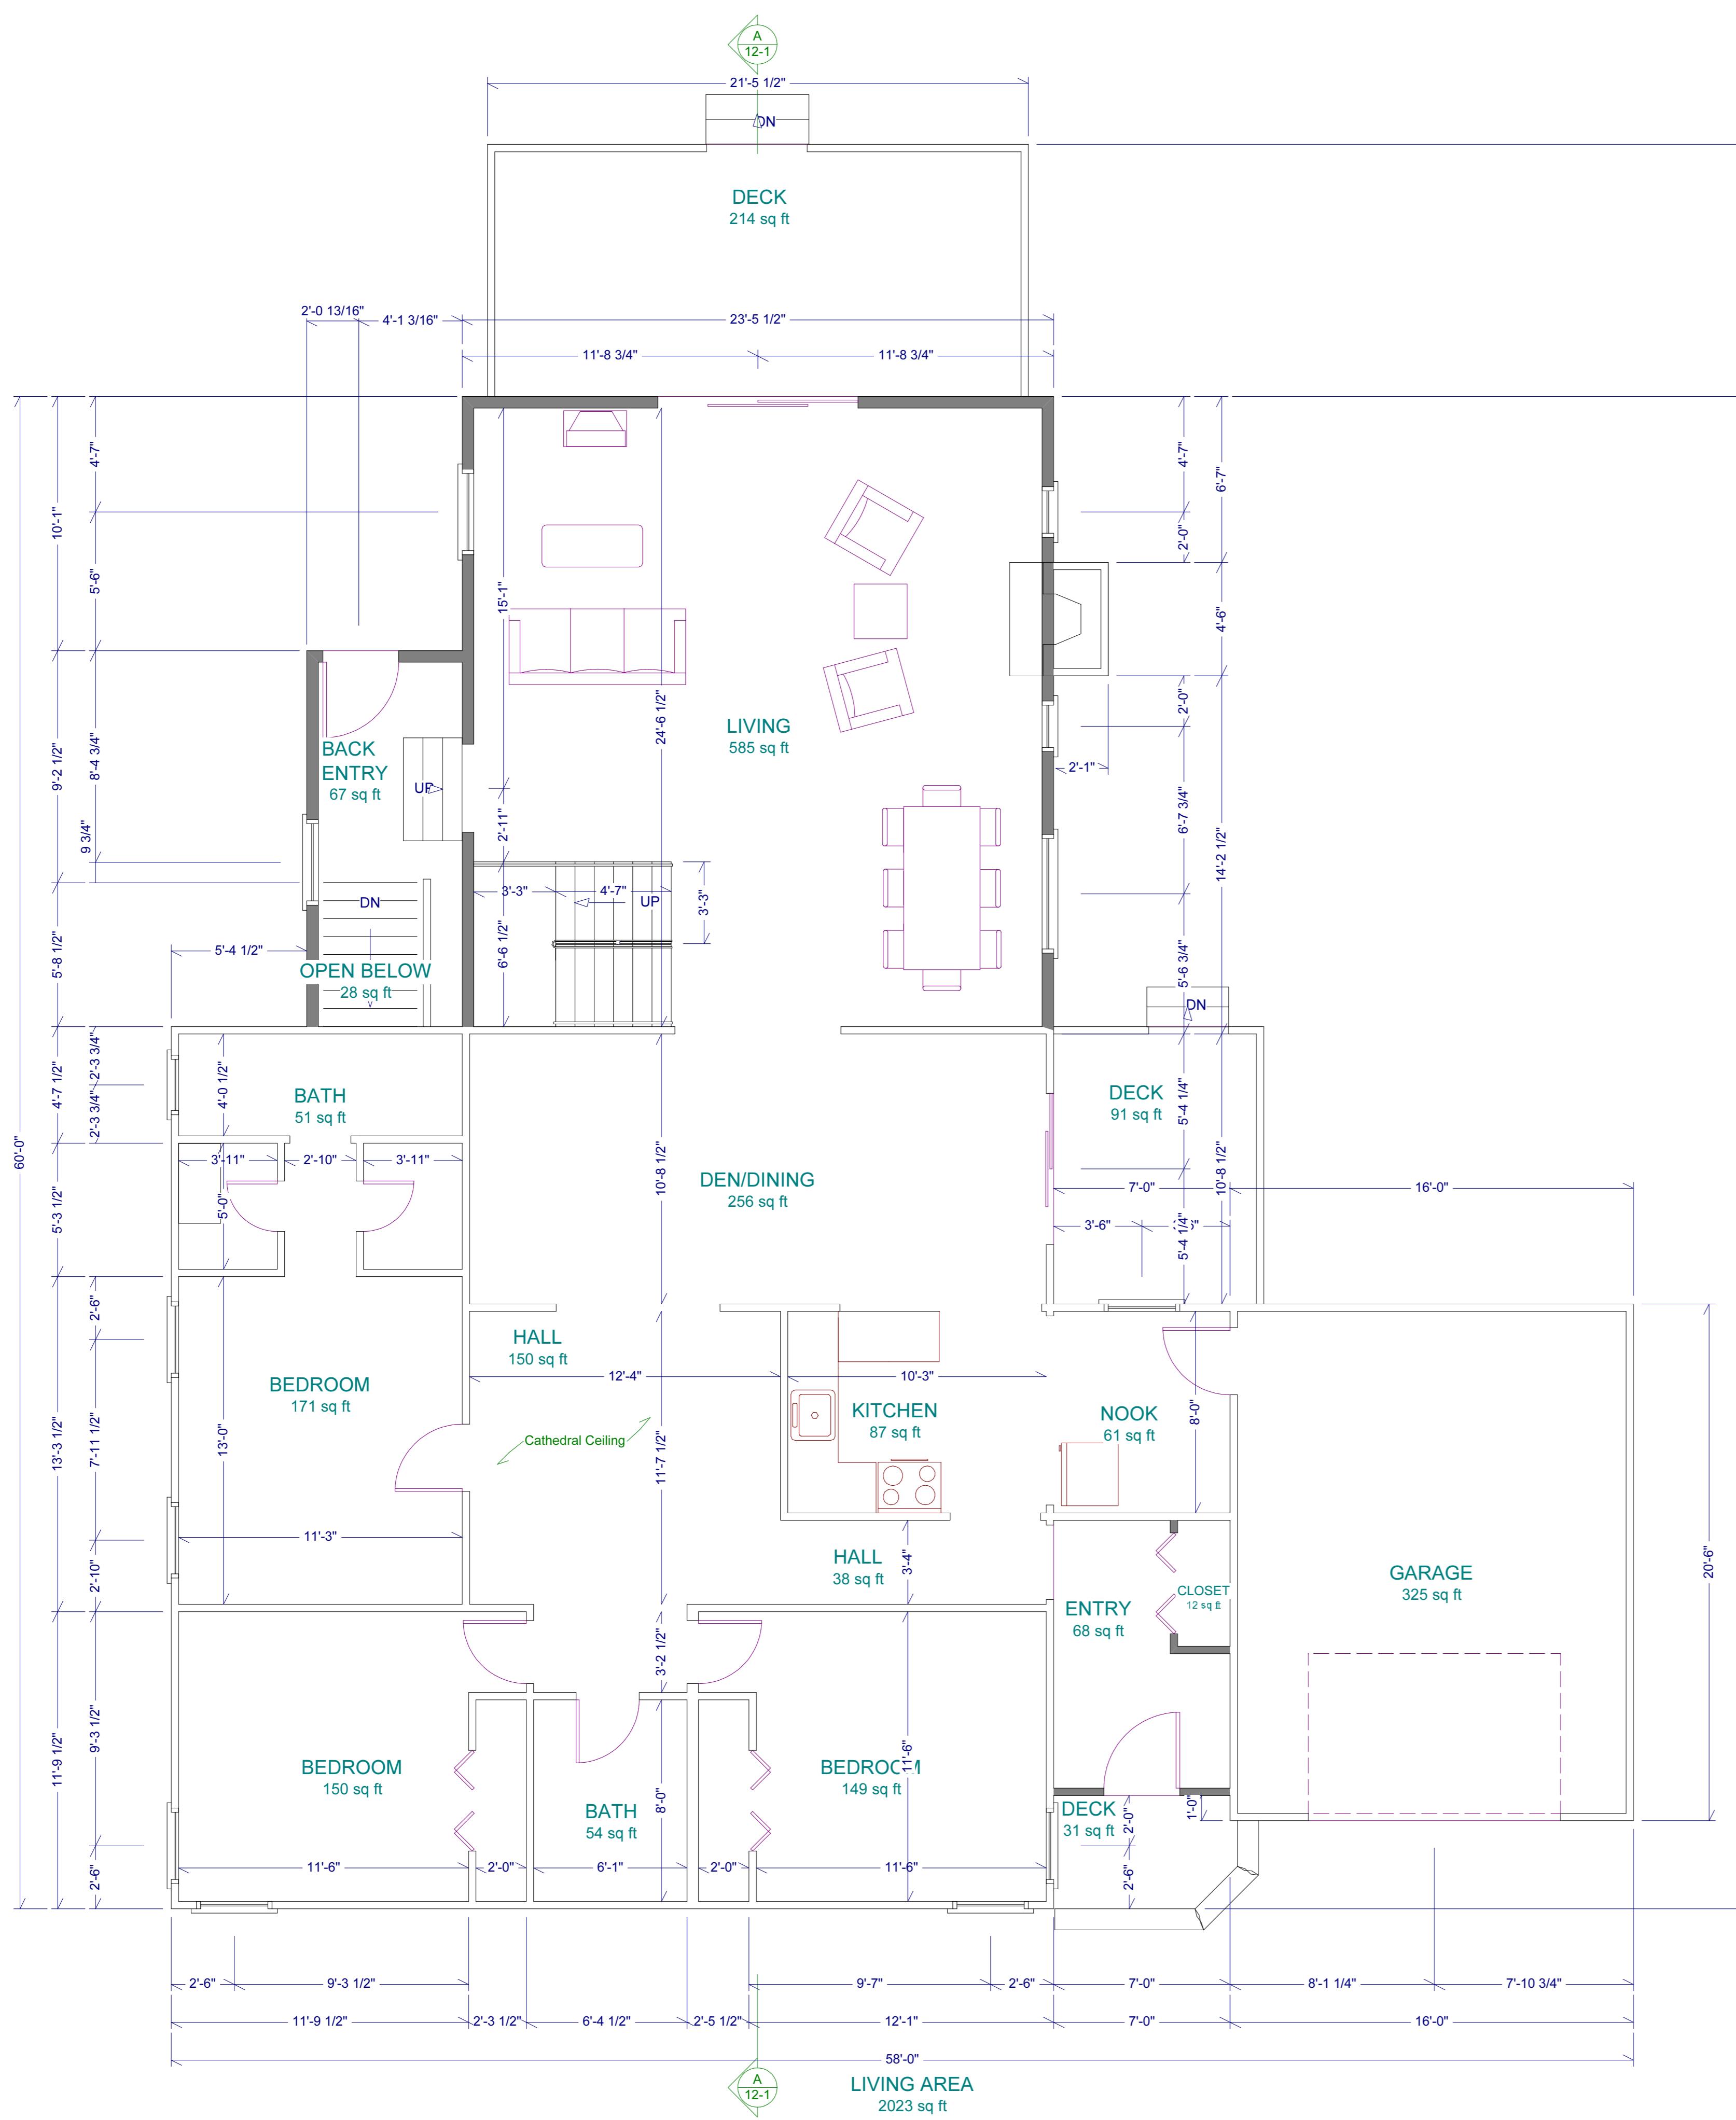

# Existing First Floor Plan

1/16" = 1'

Copyright (c) 2003. All rights reserved.

# Ada & David Kohlus Residence

Copyright (c) 2008, All rights reserved.


# David A. Webb, Inc.

Design, Drafting, Engineering,  
General Contracting

516 - 982 - 8502

Revision 2 1

<p>Ada &amp; David Kohlus Residence Montauk, NY</p> <p>First Floor Plan</p>		Revision 2.1	<p>Copyright (c) 2003, All rights reserved.</p> <p><b>David A. Webb, Inc.</b></p> <p>Design, Drafting, Engineering, General Contracting</p> <p>516 - 982 - 8502</p>		
Date	Drawn by		Scale	Sheet	
3/5/03	DW	1/8" = 1'	4		

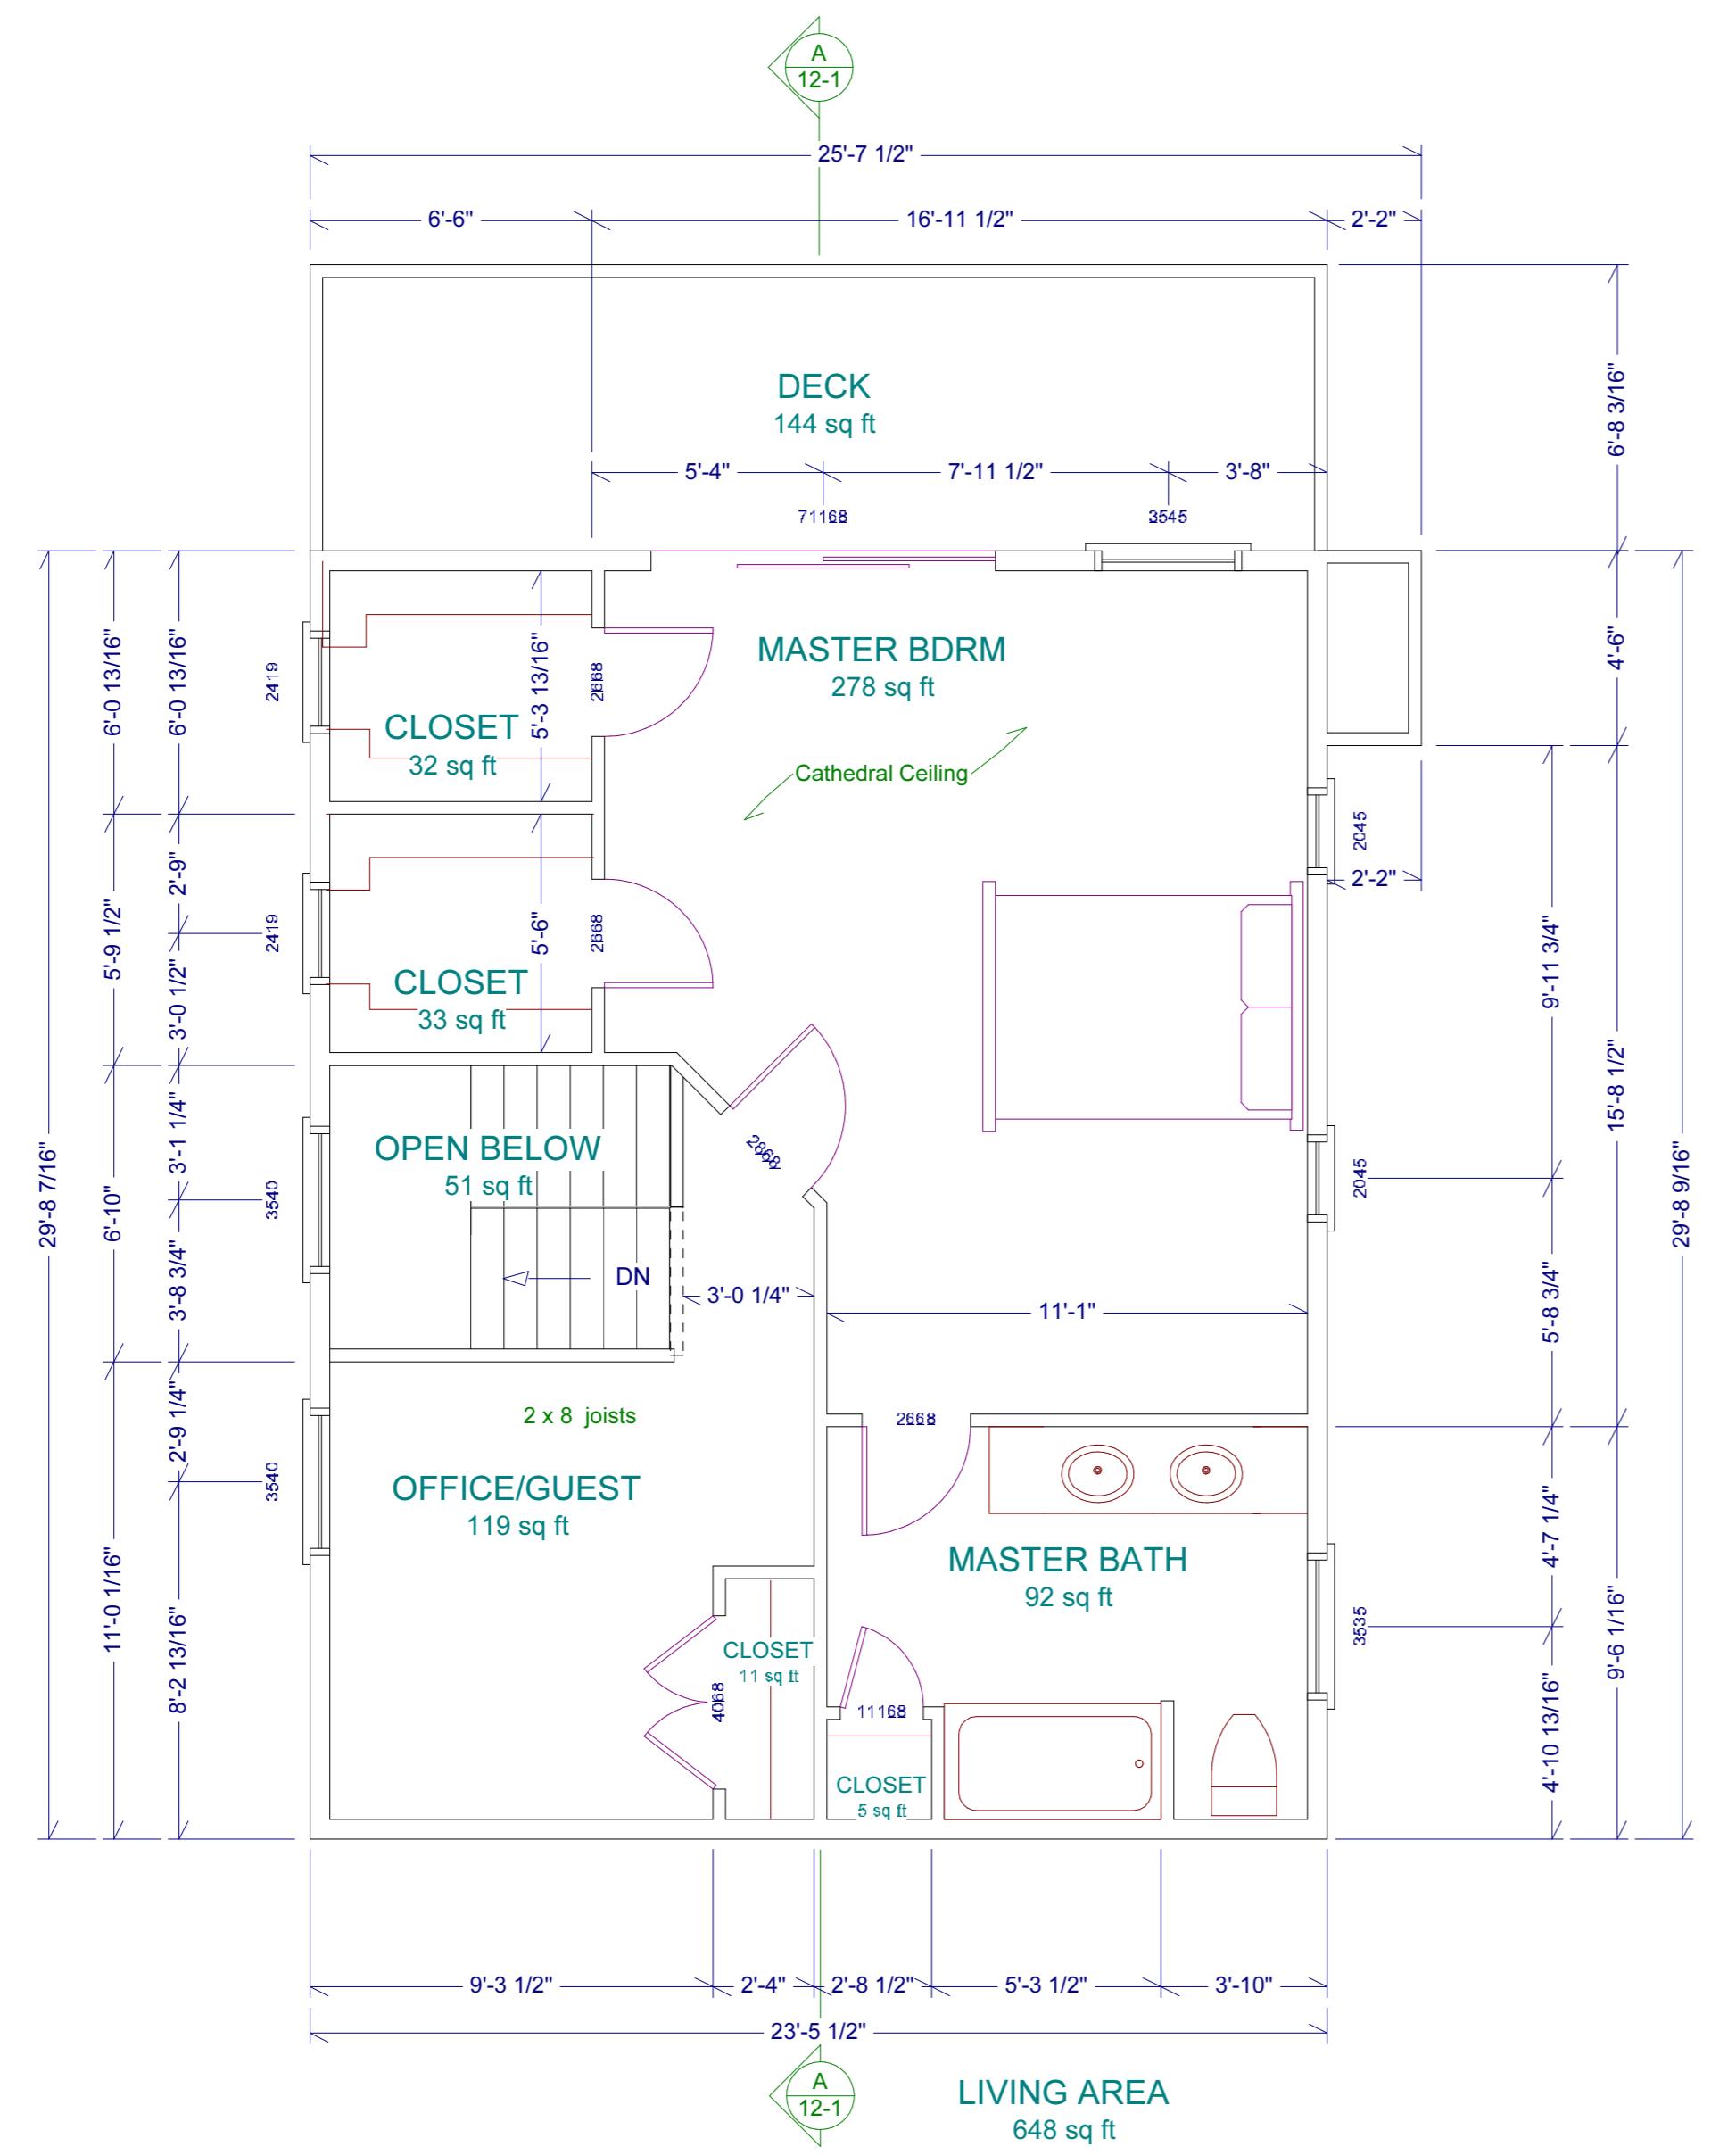

Room	Floor	Flooring	Walls	Ceiling	Trim
LR	1	Red Oak, Clr WaterBase	Sheetrock, flat white	Sheetrock flat white	Clam, gloss white
Deck	1	5/4 x 4 Clr Cedar	Sheetrock, flat white	Sheetrock flat white	Clam, gloss white
Entry	1	Red Oak, Clr WaterBase	Sheetrock, flat white	Sheetrock flat white	Clam, gloss white
Entry Deck	1	5/4 x 4 Clr Cedar	Sheetrock flat white	Sheetrock flat white	Clam, gloss white
Back Entry	1	Title ??	Sheetrock, flat white	Sheetrock flat white	Clam, gloss white
MBr	2	Carpet ??	Sheetrock, flat white	Sheetrock flat white	Clam, gloss white
WIC 182	2	Carpet ??	Sheetrock, flat white	Sheetrock flat white	Clam, gloss white
Deck	1	5/4 x 4 Clr Cedar	Sheetrock flat white	Sheetrock flat white	Clam, gloss white
MBth	2	Title ??	MR Sheetrock, eggshell white	MR Sheetrock eggshell white	Clam, gloss white
Closet	2	Title ??	MR Sheetrock, eggshell white	MR Sheetrock eggshell white	Clam, gloss white
Office	2	Red Oak, Clr WaterBase	Sheetrock, flat white	Sheetrock flat white	Clam, gloss white
Closet	2	Red Oak, Clr WaterBase	Sheetrock, flat white	Sheetrock flat white	Clam, gloss white

WINDOW SCHEDULE							
NUMBER	QTY	FLOOR	SIZE	DIMENSIONS	R/O	DESCRIPTION	CODE
W00	1	1	2420	28 3/8"X24 1/8"	28 7/8X24 5/8	AWNING	AN251
W01	1	1	3545	40 3/4"X52 13/16"	41 1/4X53 5/16	DBL CASEMENT	CN245
W02	2	1	2050	24 1/8"X59 7/8"	24 5/8X60 3/8	SNGL CASEMENT-HR	C115
W03	1	1	4950	56 1/2"X59 7/8"	57X60 3/8	DBL CASEMENT-LHL/RHR	CW25
W04	1	1	3550	40 3/4"X59 7/8"	41 1/4X60 3/8	DBL CASEMENT	CN25
W05	1	2	3535	40 3/4"X40 7/8"	41 1/4X41 3/8	DBL CASEMENT	CN235
W06	2	2	2045	24 1/8"X52 7/8"	24 5/8X53 3/8	SNGL CASEMENT-HR	C145
W07	2	2	2419	28 3/8"X20 1/2"	28 7/8X21	AWNING	AN251
W08	2	2	3540	40 3/4"X48 1/2"	41 1/4X48 1/2	DBL CASEMENT	CN24
W09	1	2	3545	40 3/4"X52 7/8"	41 1/4X53 3/8	DBL CASEMENT	CN245

DOOR SCHEDULE								
NUMBER	QTY	FLOOR	SIZE	DIMENSIONS	R/O	DESCRIPTION	THICKNESS	CODE
D00	1	1	3068	36X79 1/2X1 3/4"	36 7/8X80	EXT. HINGED-GLASS	1 3/4	FWH3168AR
D01	1	1	3068	36 1/8X79 1/2X1 3/4"	37X80	EXT. HINGED-GLASS	1 3/4	FWH3168AR
D02	1	1	71168	95 1/4X79 1/2"	96X80	EXT. SLIDER-GLASS	1 3/4	FWG 8068L
D03	1	1	4068	24X80"	49X81 1/2"	BI FOLD	1 3/8	
D04	1	2	4068	24X80X1 3/8"	49X81 1/2"	HINGED	1 3/8	
D05	1	2	11168	23X80X1 3/8"	24X81 1/2"	HINGED	1 3/8	
D06	1	2	2668	32X80X1 3/8"	33X81 1/2"	HINGED	1 3/8	
D07	3	2	2668	30X80X1 3/8"	31X81 1/2"	HINGED	1 3/8	
D08	1	2	71168	95 1/4X79 1/2"	96X80	EXT. SLIDER-GLASS	1 3/4	FWG 8068L

Ada & David Kohlus  
Residence  
Montauk, NY

Revision 2.1

Copyright (c) 2003. All rights reserved.  
David A. Webb, Inc.  
Design, Drafting, Engineering,  
General Contracting  
516 - 982 - 8502

Second Floor Plan & Specifications

Date	Drawn by	Scale	Sheet
3/5/03	DW	1/8" = 1'	5



Ada & David Kohlus  
Residence  
Montauk, NY

Revision 2.1

Copyright (c) 2003. All rights reserved.  
**David A. Webb, Inc.**  
Design, Drafting, Engineering,  
General Contracting  
516 - 982 - 8502

Elevations

Date	Drawn by	Scale	Sheet
3/5/03	DW	1/8" = 1'	6



Southeast Side



Northeast Side


Ada & David Kohlus  
Residence  
Montauk, NY

Revision 2.1


Copyright (c) 2003. All rights reserved.  
**David A. Webb, Inc.**  
Design, Drafting, Engineering,  
General Contracting  
516 - 982 - 8502

Elevations

Date	Drawn by	Scale	Sheet
3/5/03	DW	1/8" = 1'	7

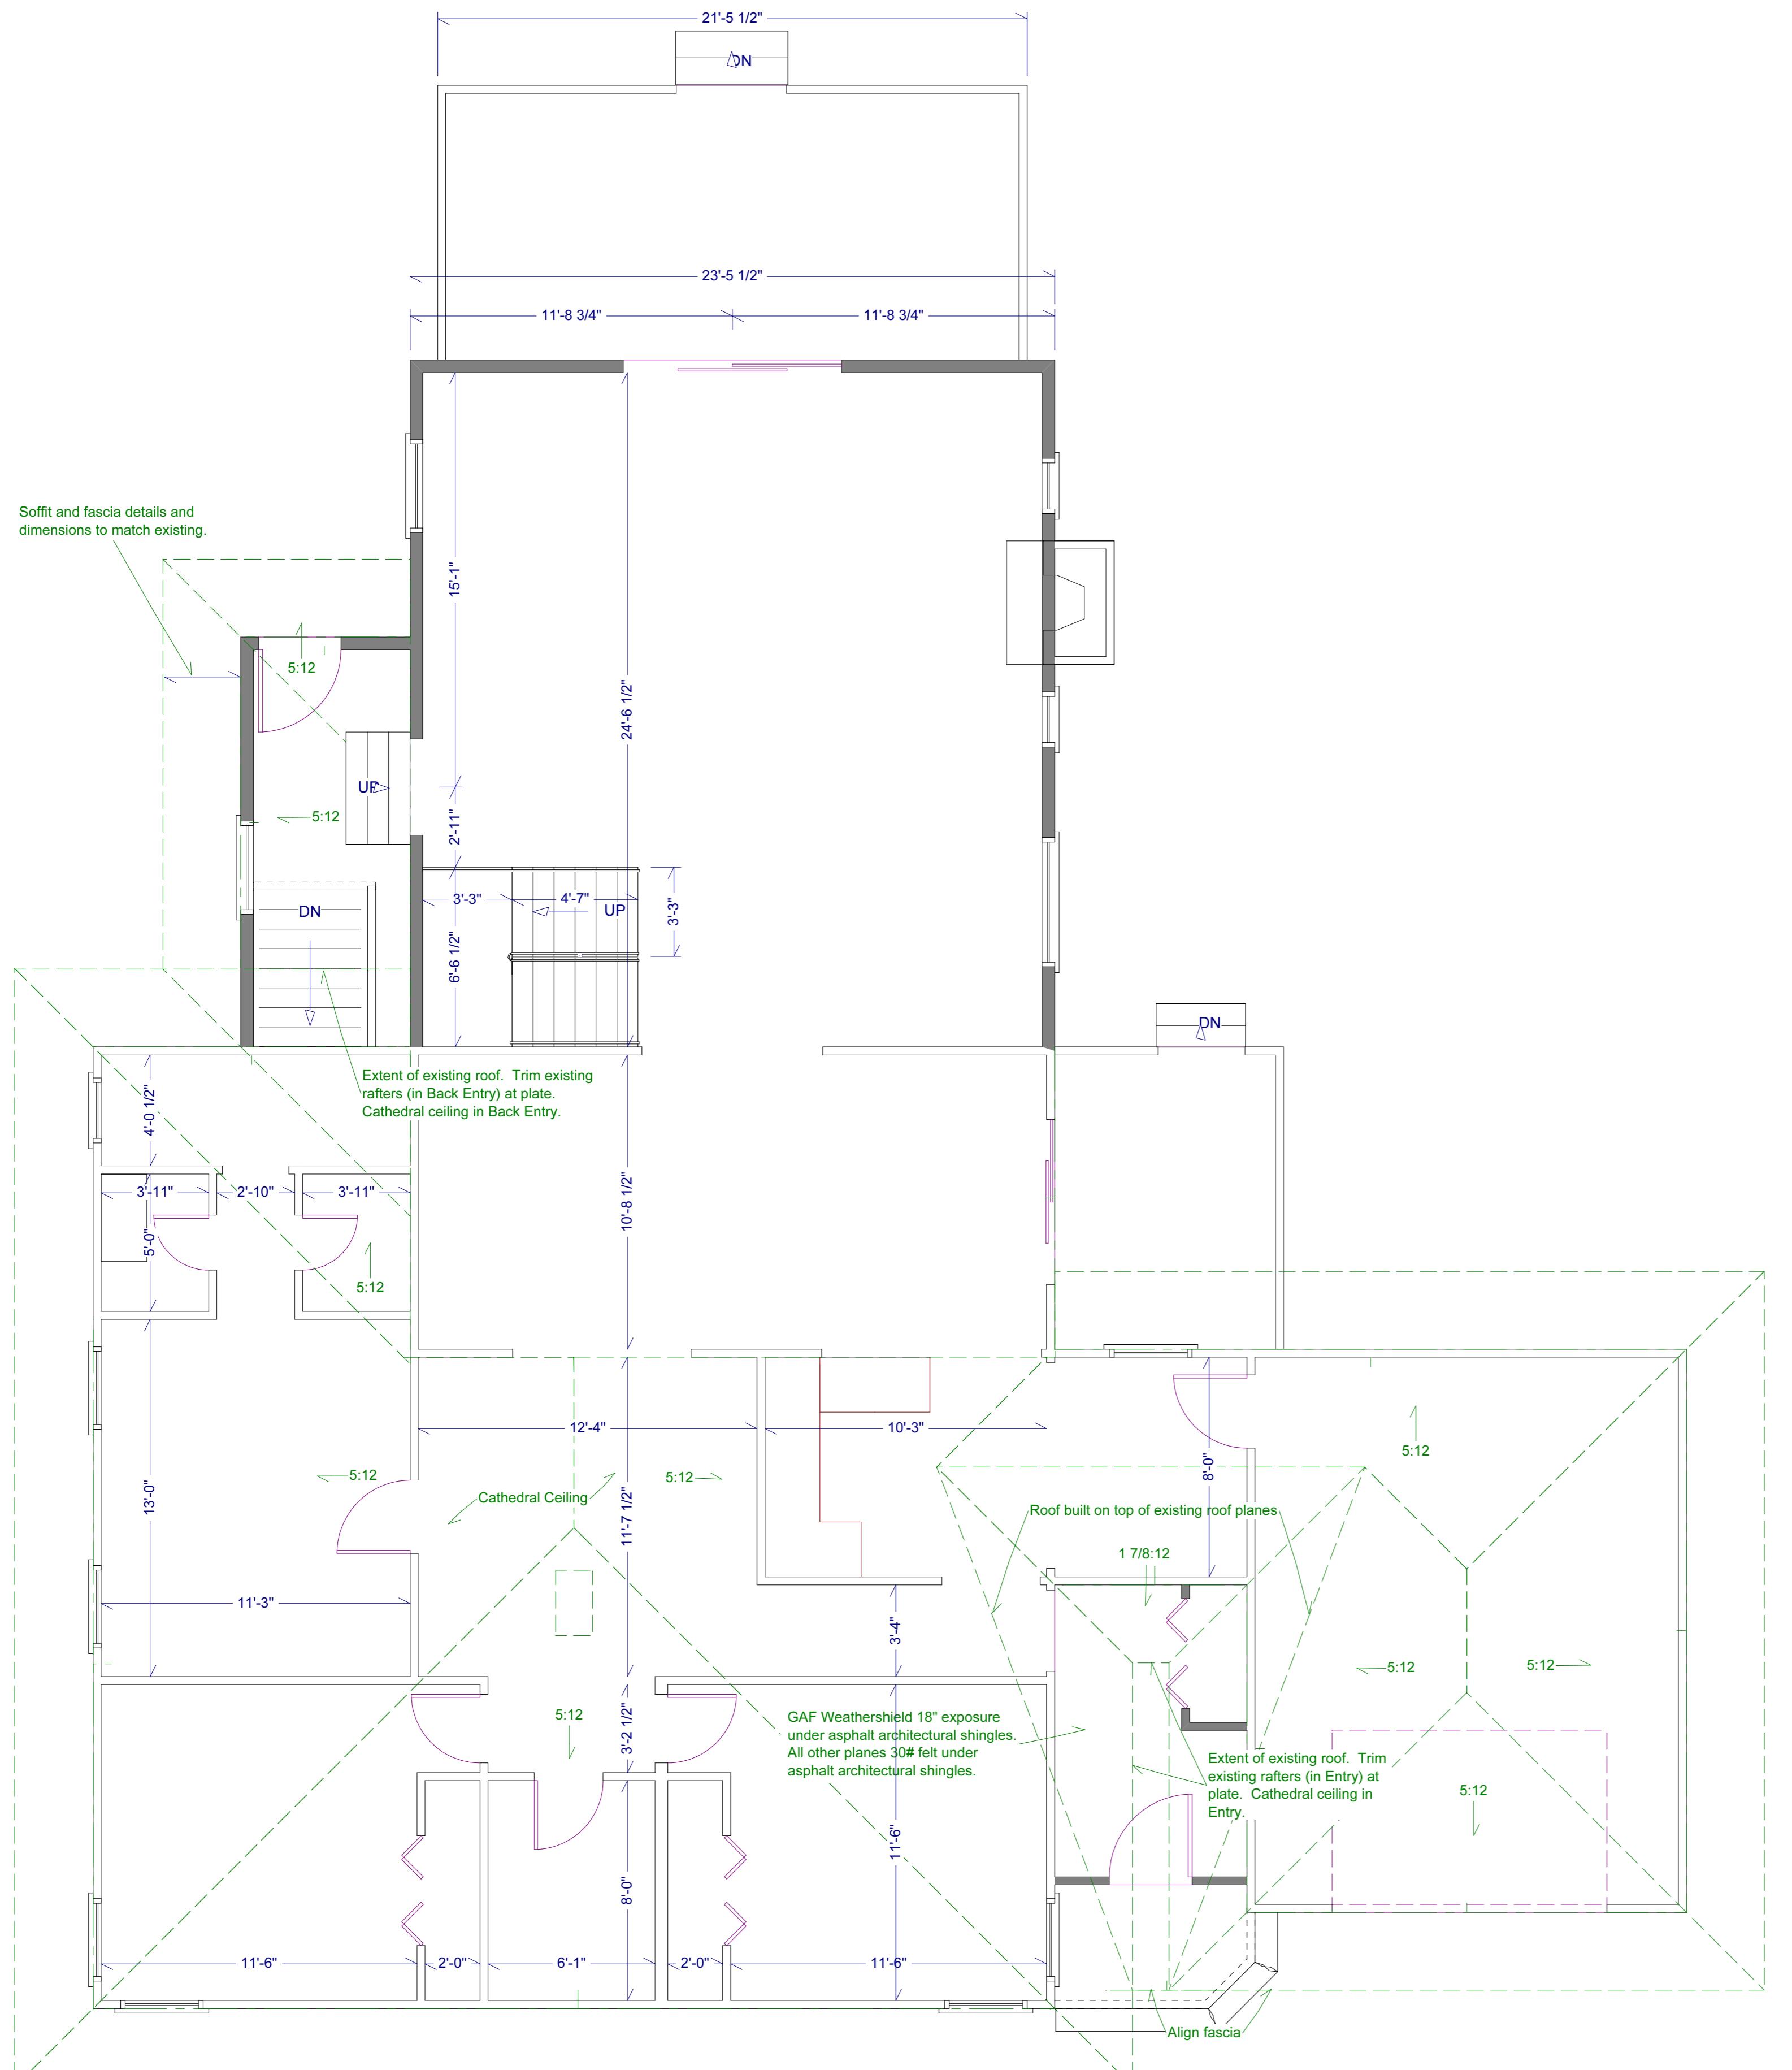

# First Floor

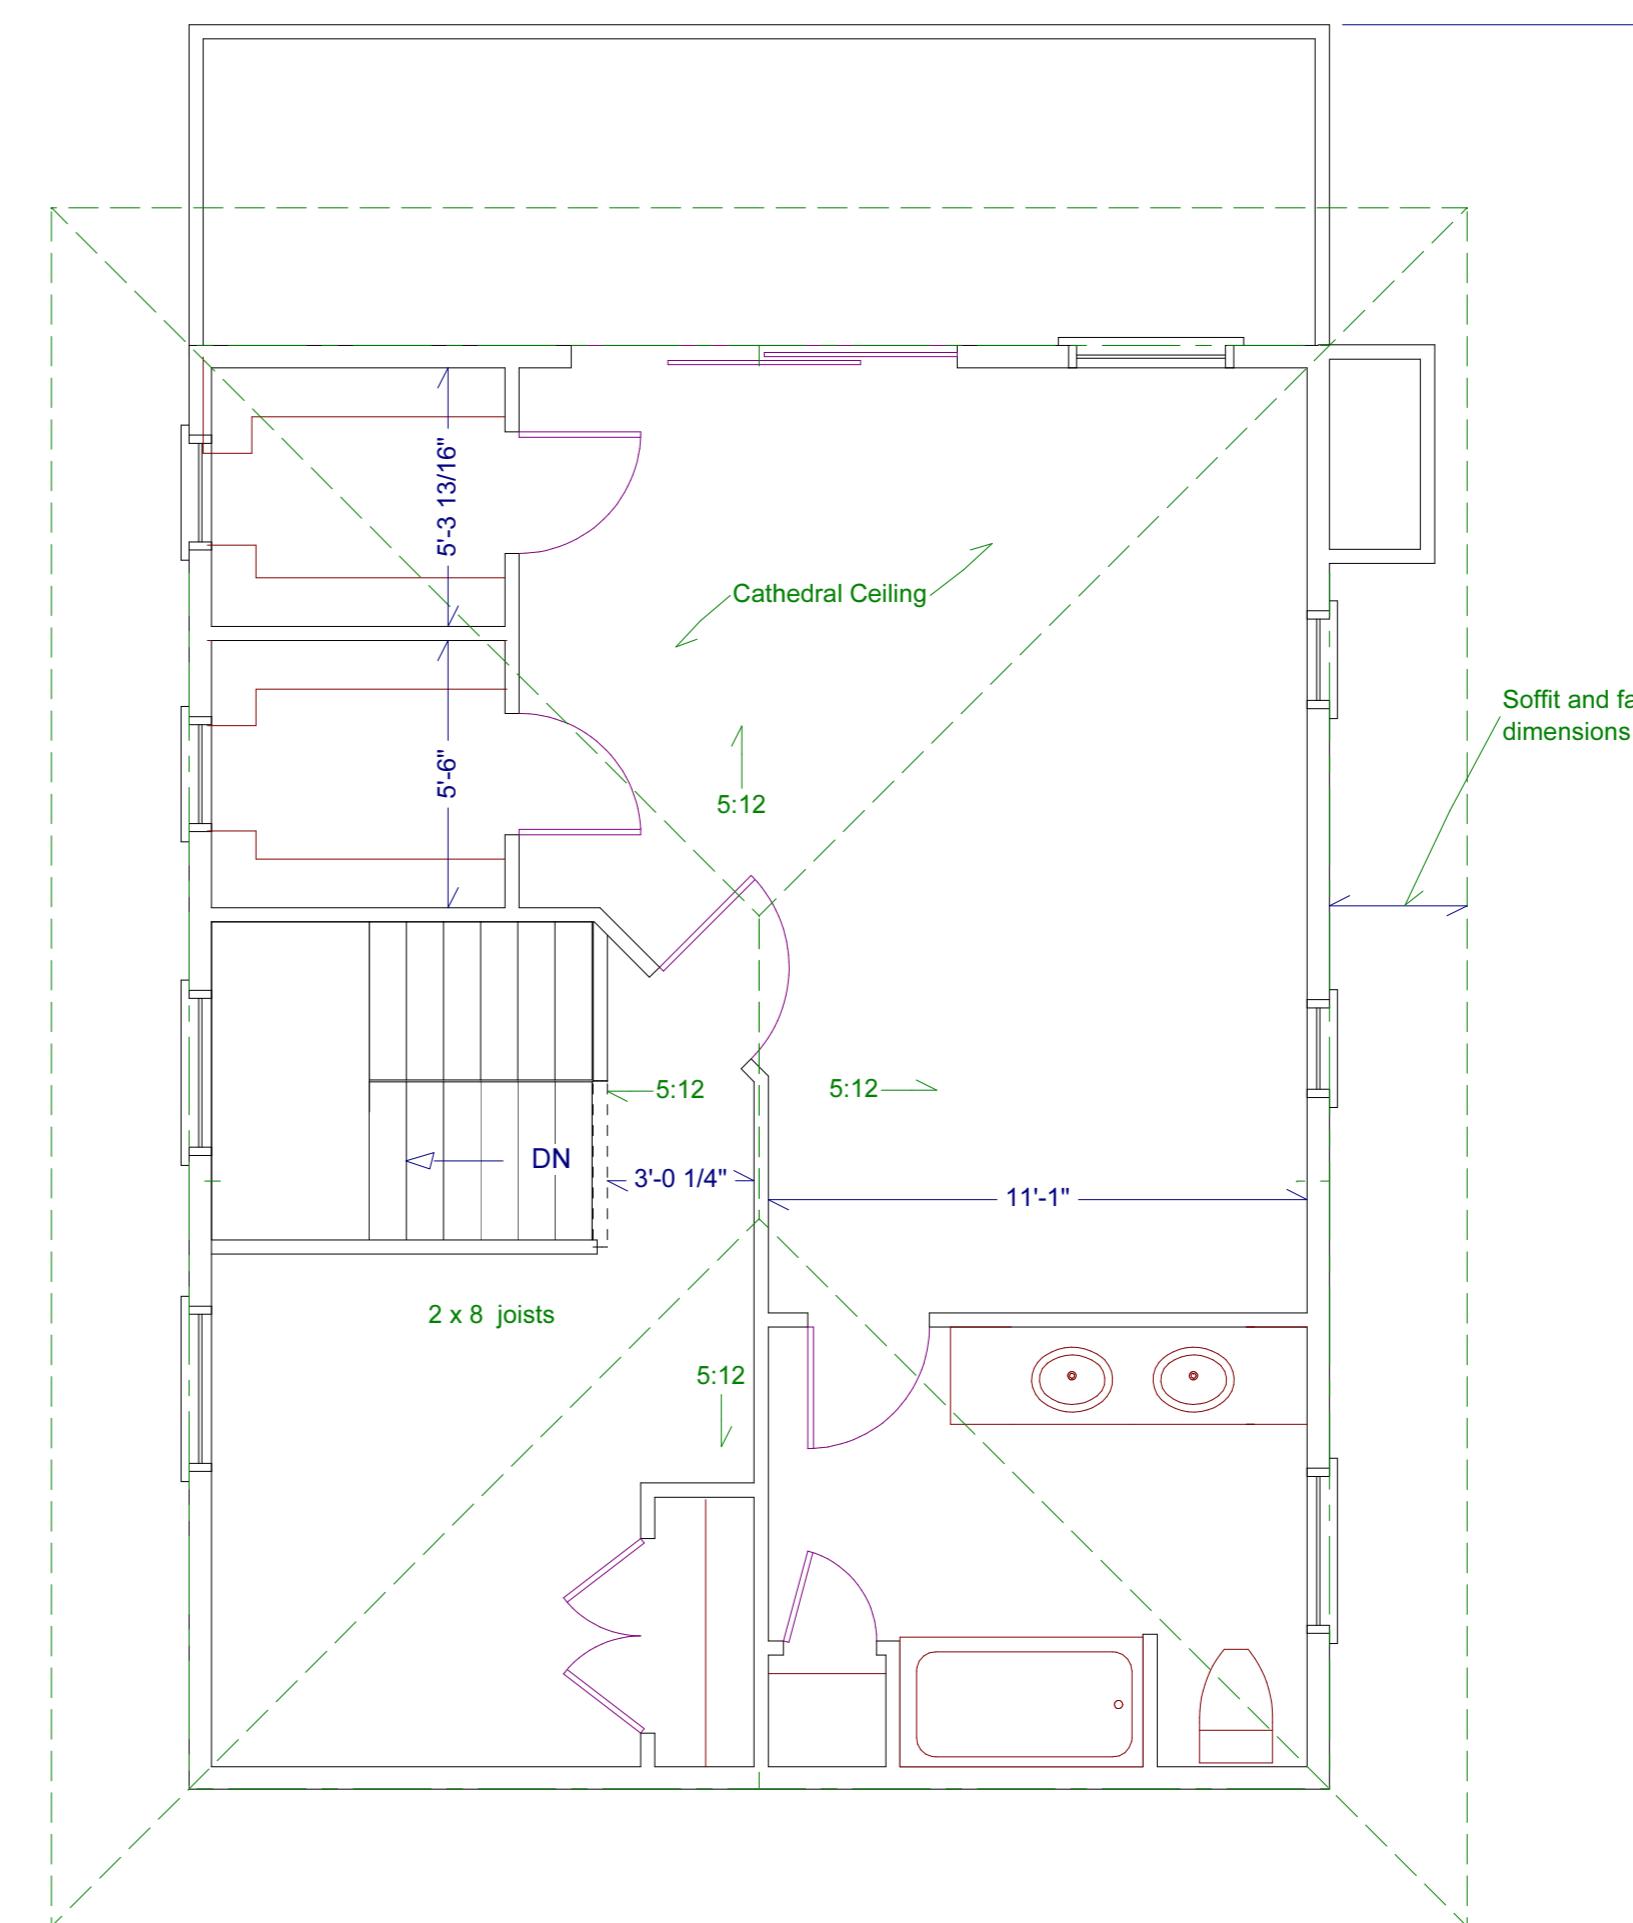

# Second Floor

Copyright (c) 2003. All rights reserved.

# Ada & David Kohlus Residence

Copyright (c) 2003, All rights reserved.


# David A. Webb, Inc.

Design, Drafting, Engineering,  
General Contracting

516 - 982 - 8502

Revision 2.1

<p>Ada &amp; David Kohlus Residence Montauk, NY</p> <p>Roof plans</p>		Revision 2.1	<p>Copyright (c) 2003, All rights reserved.</p> <p><b>David A. Webb, Inc.</b></p> <p>Design, Drafting, Engineering, General Contracting</p> <p>516 - 982 - 8502</p>		
Date	Drawn by		Scale	Sheet	
3/5/03	DW	1/8" = 1'	8		

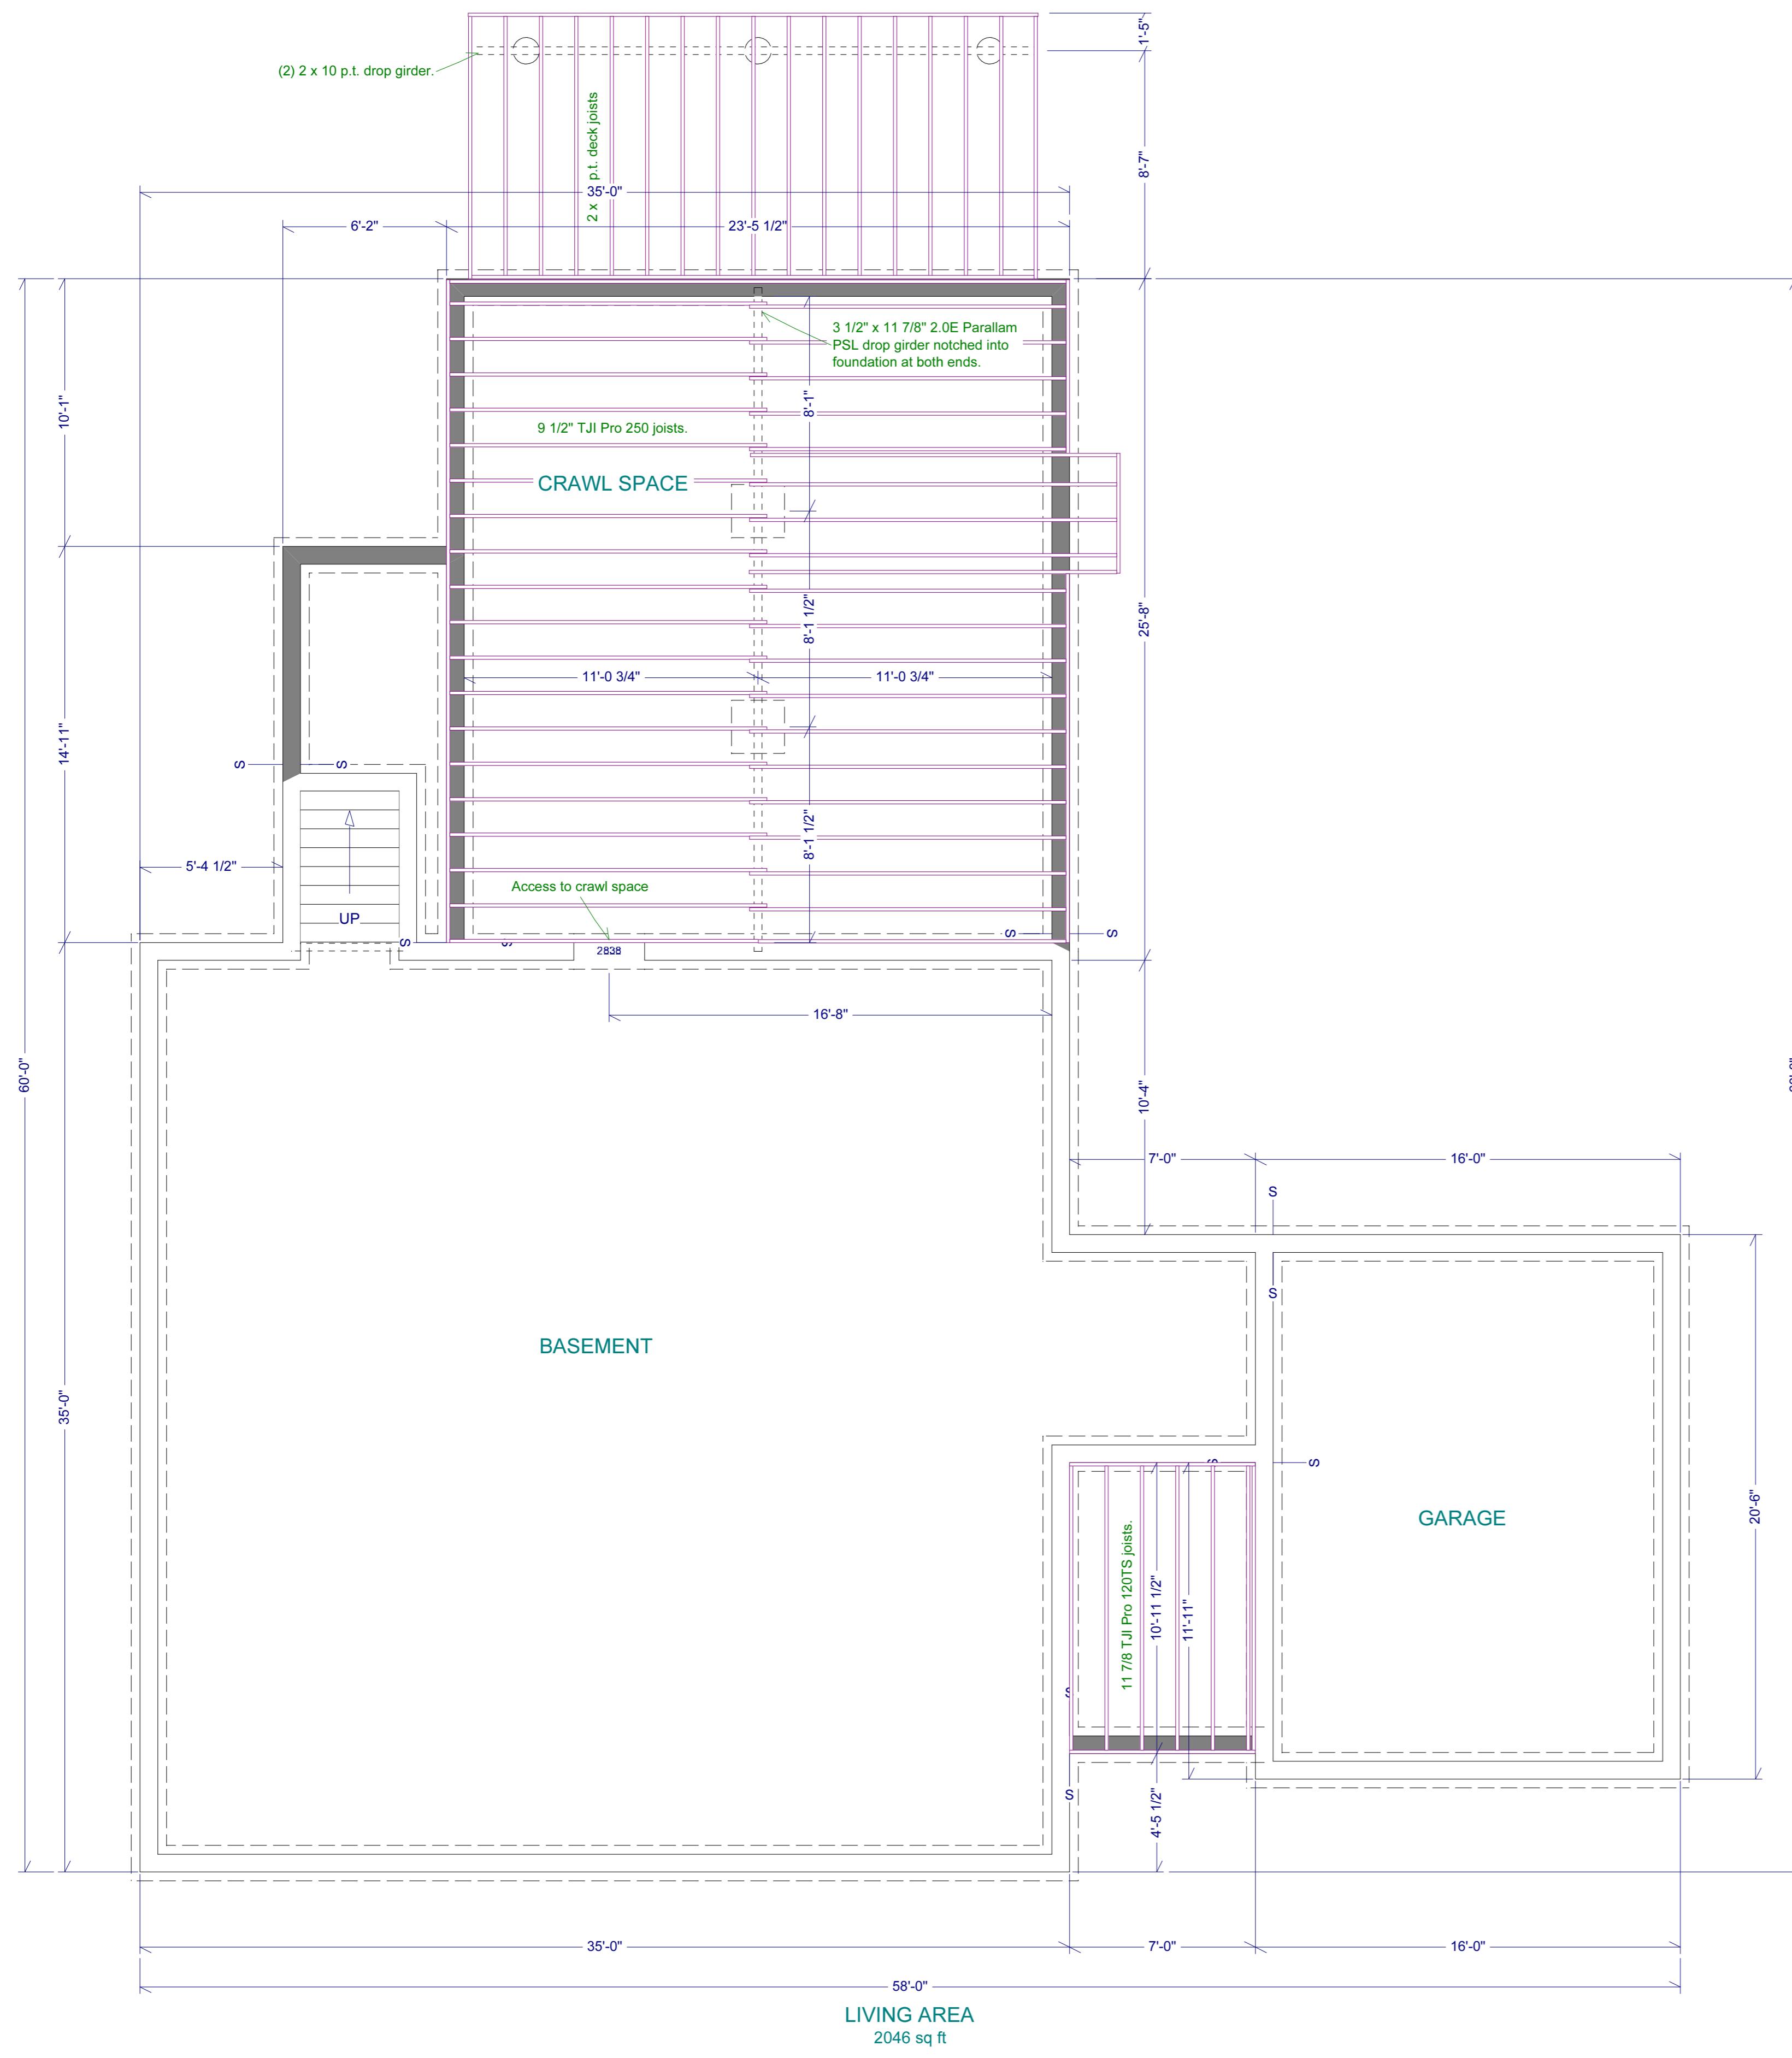

Ada & David Kohlus  
Residence  
Montauk, NY

First Floor Framing Plan


Revision 2.1

Copyright (c) 2003. All rights reserved.  
**David A. Webb, Inc.**  
Design, Drafting, Engineering,  
General Contracting  
516 - 982 - 8502

Date	Drawn by	Scale	Sheet
3/5/03	DW	1/8" = 1'	9



Second Floor Joists

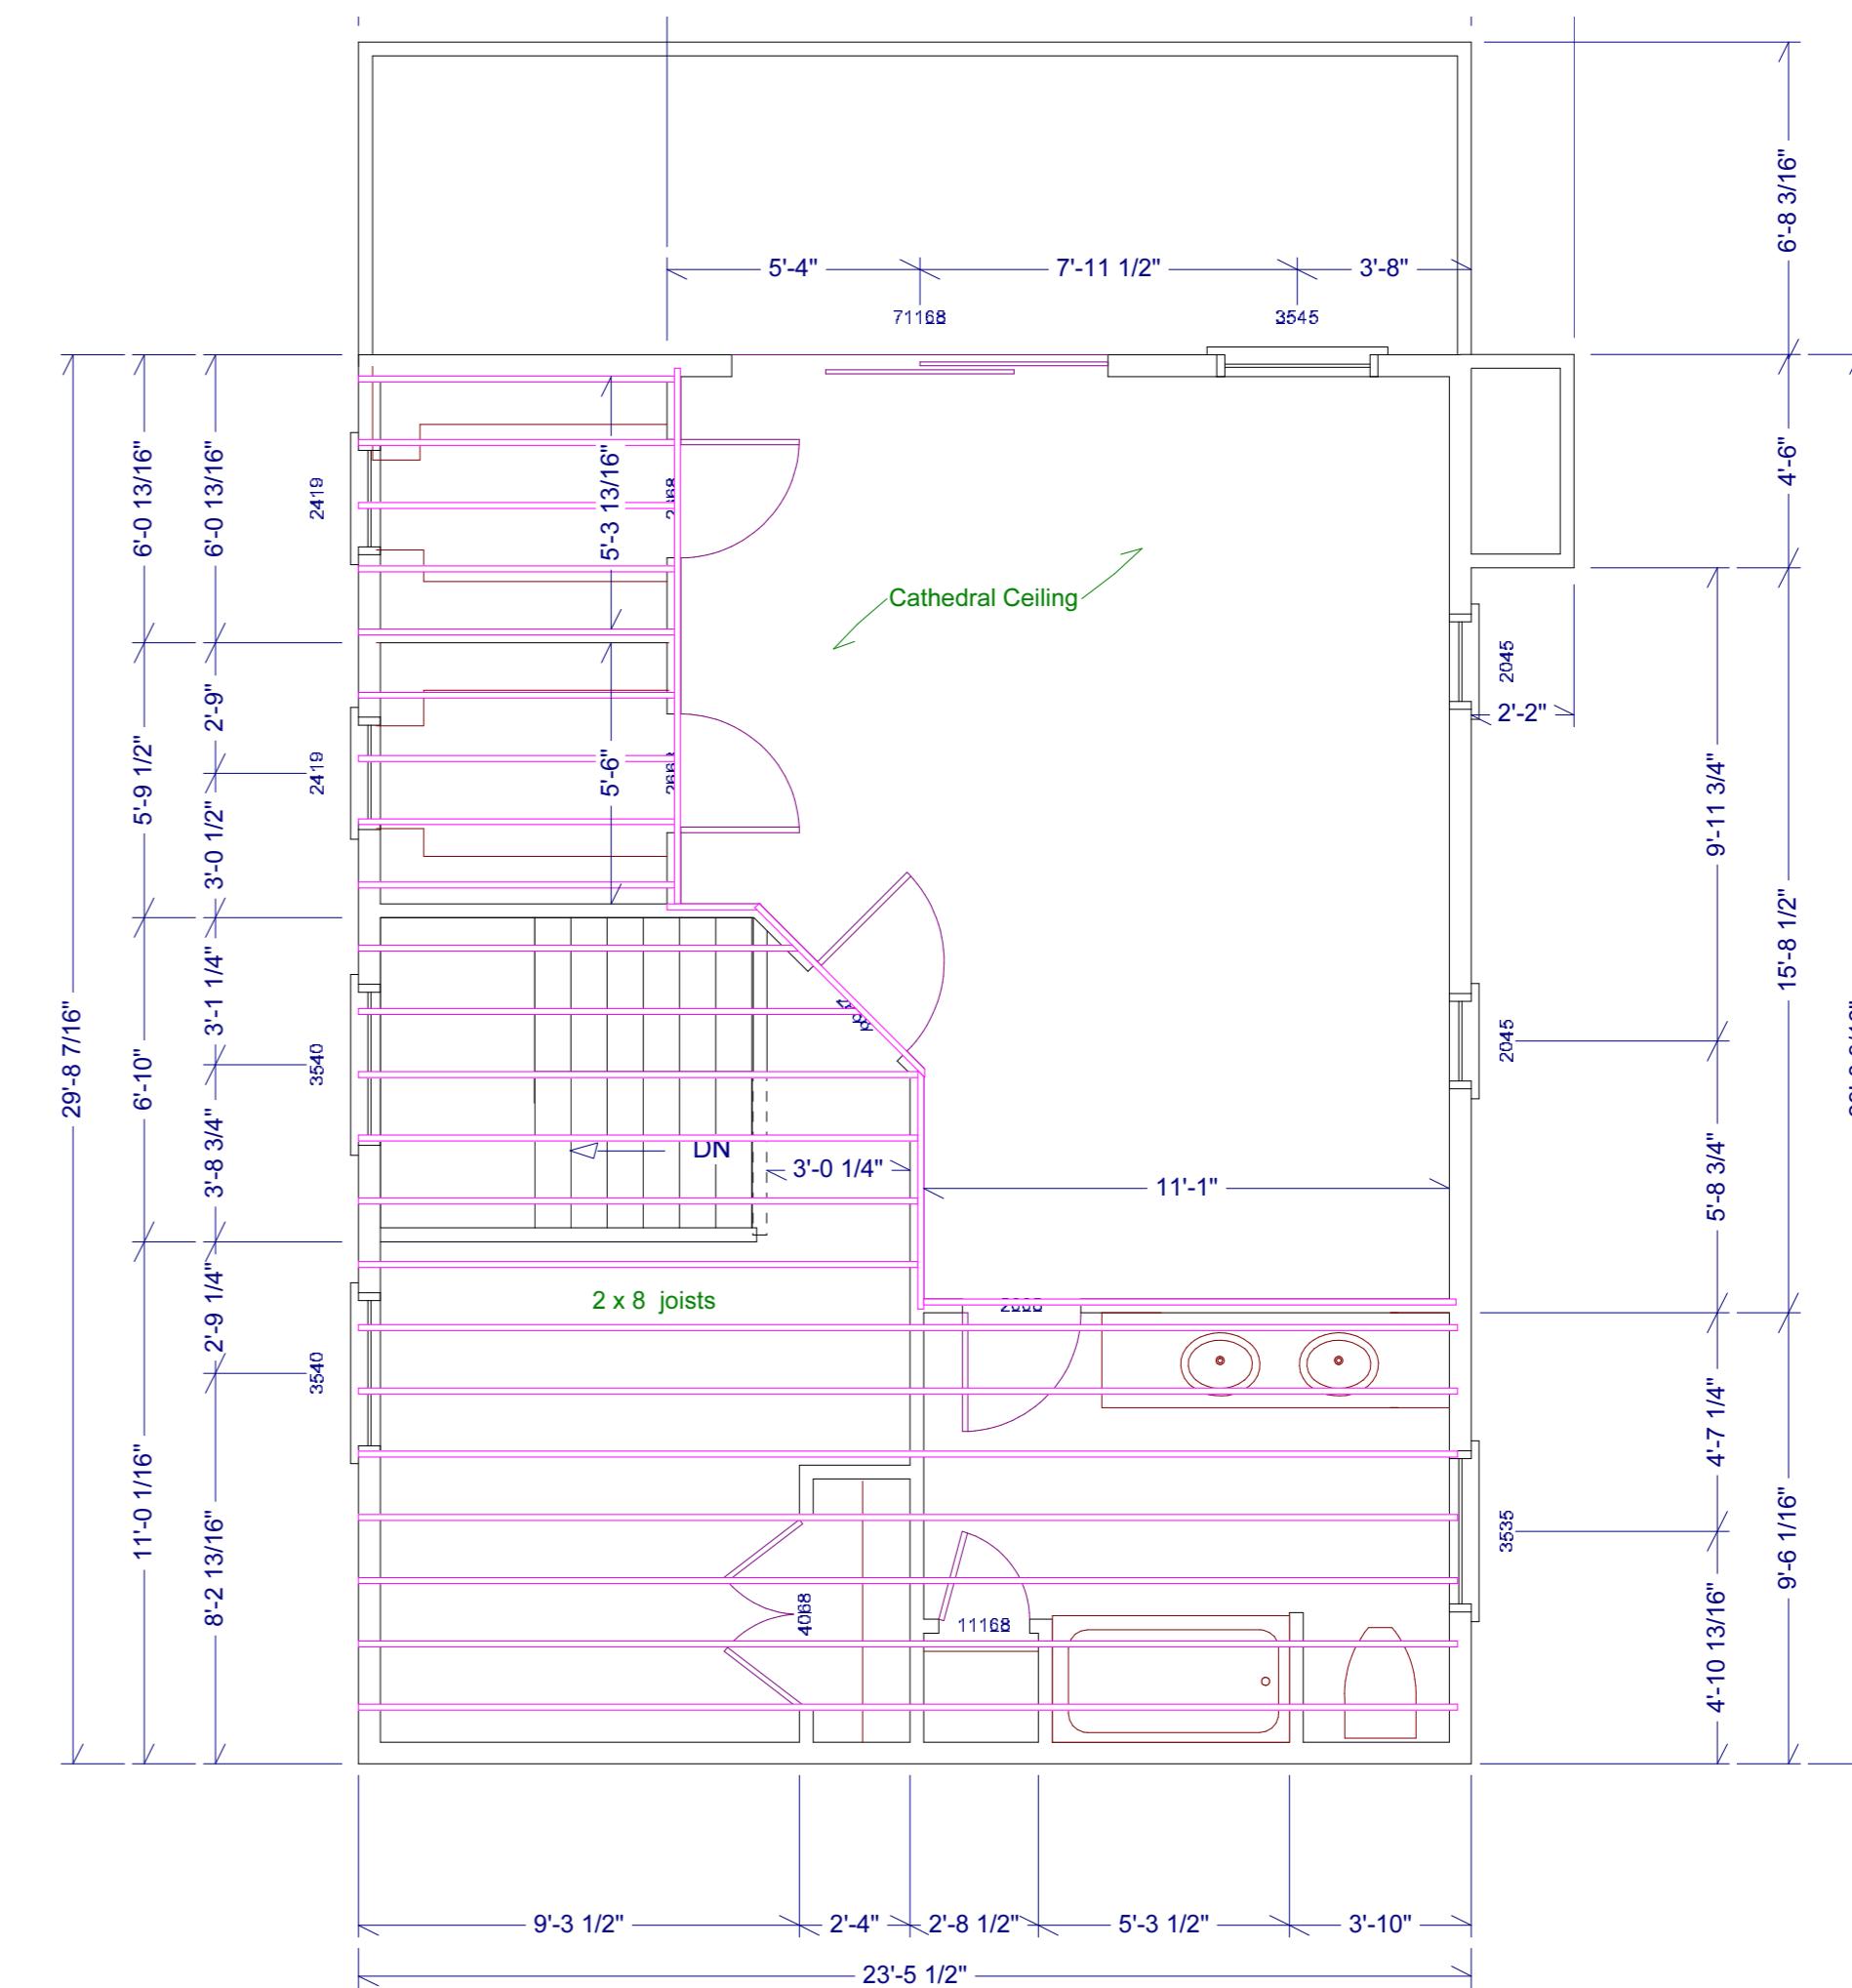

Second Floor Ceiling


Ada & David Kohlus  
Residence  
Montauk, NY

Second Floor Framing &  
Ceiling Framing Plans


Revision 2.1

Copyright (c) 2003. All rights reserved.  
David A. Webb, Inc.  
Design, Drafting, Engineering,  
General Contracting  
516 - 982 - 8502

Date	Drawn by	Scale	Sheet
3/5/03	DW	1/8" = 1'	10

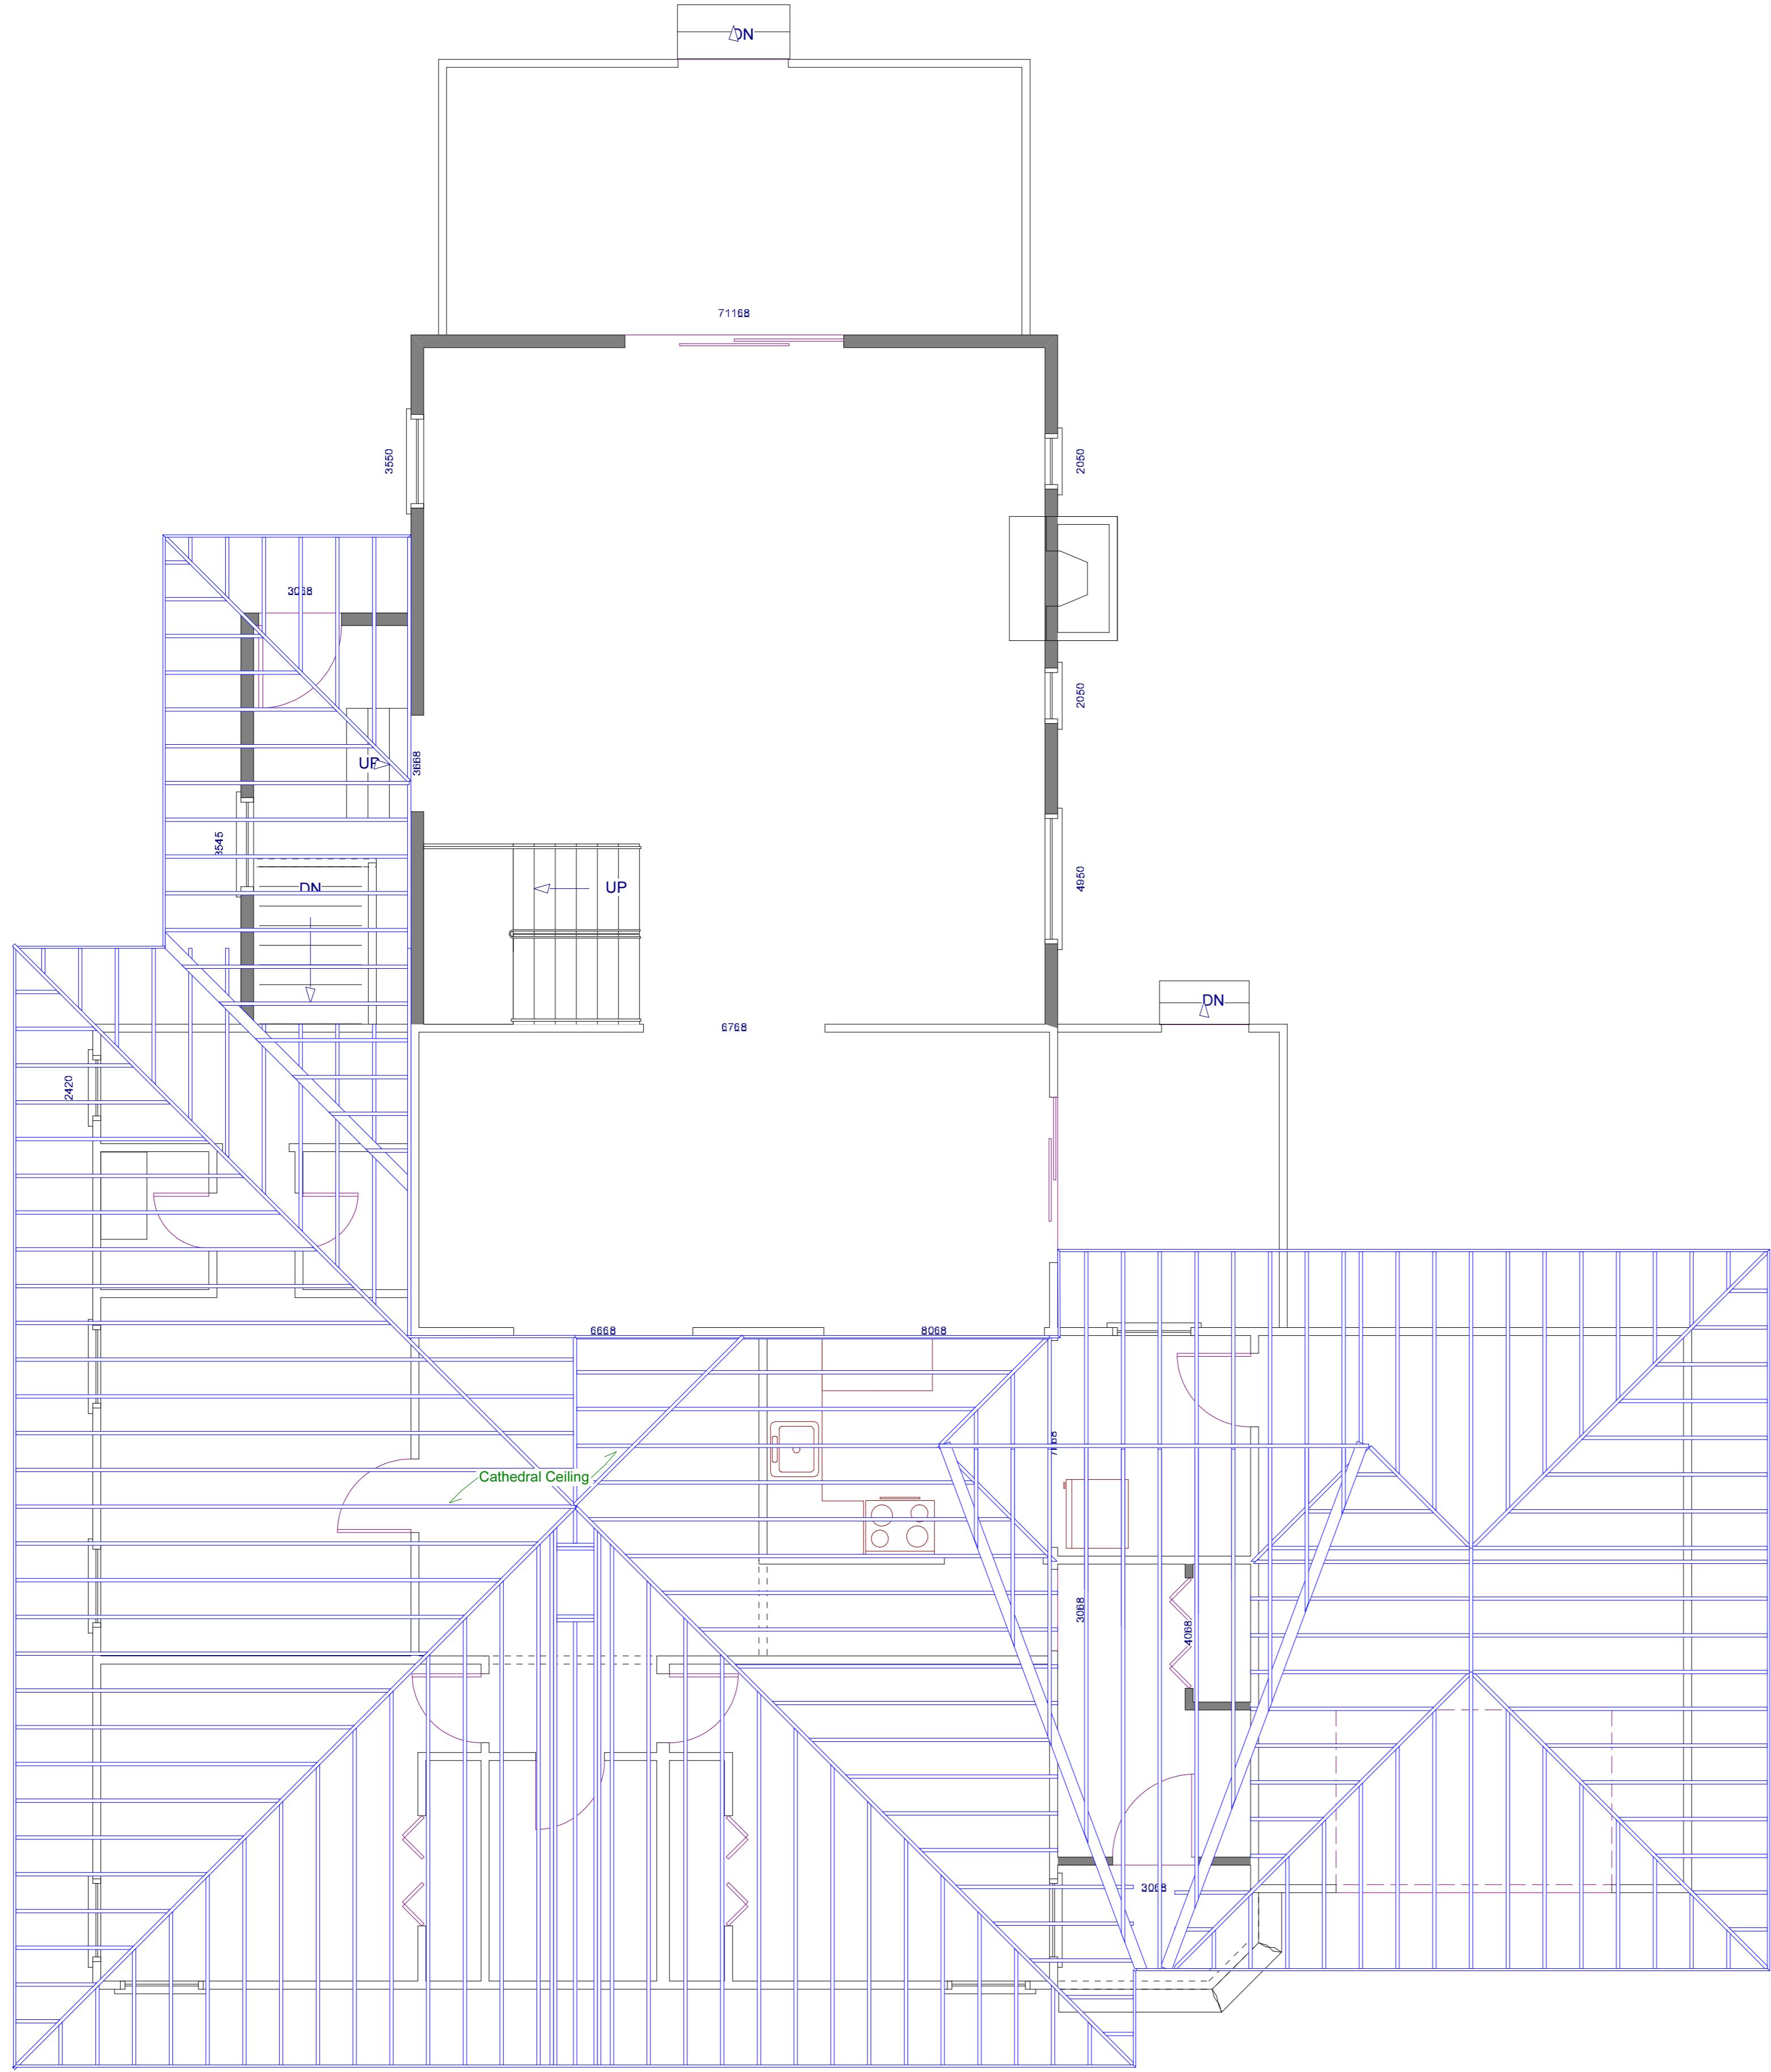

# First Floor Roof Framing

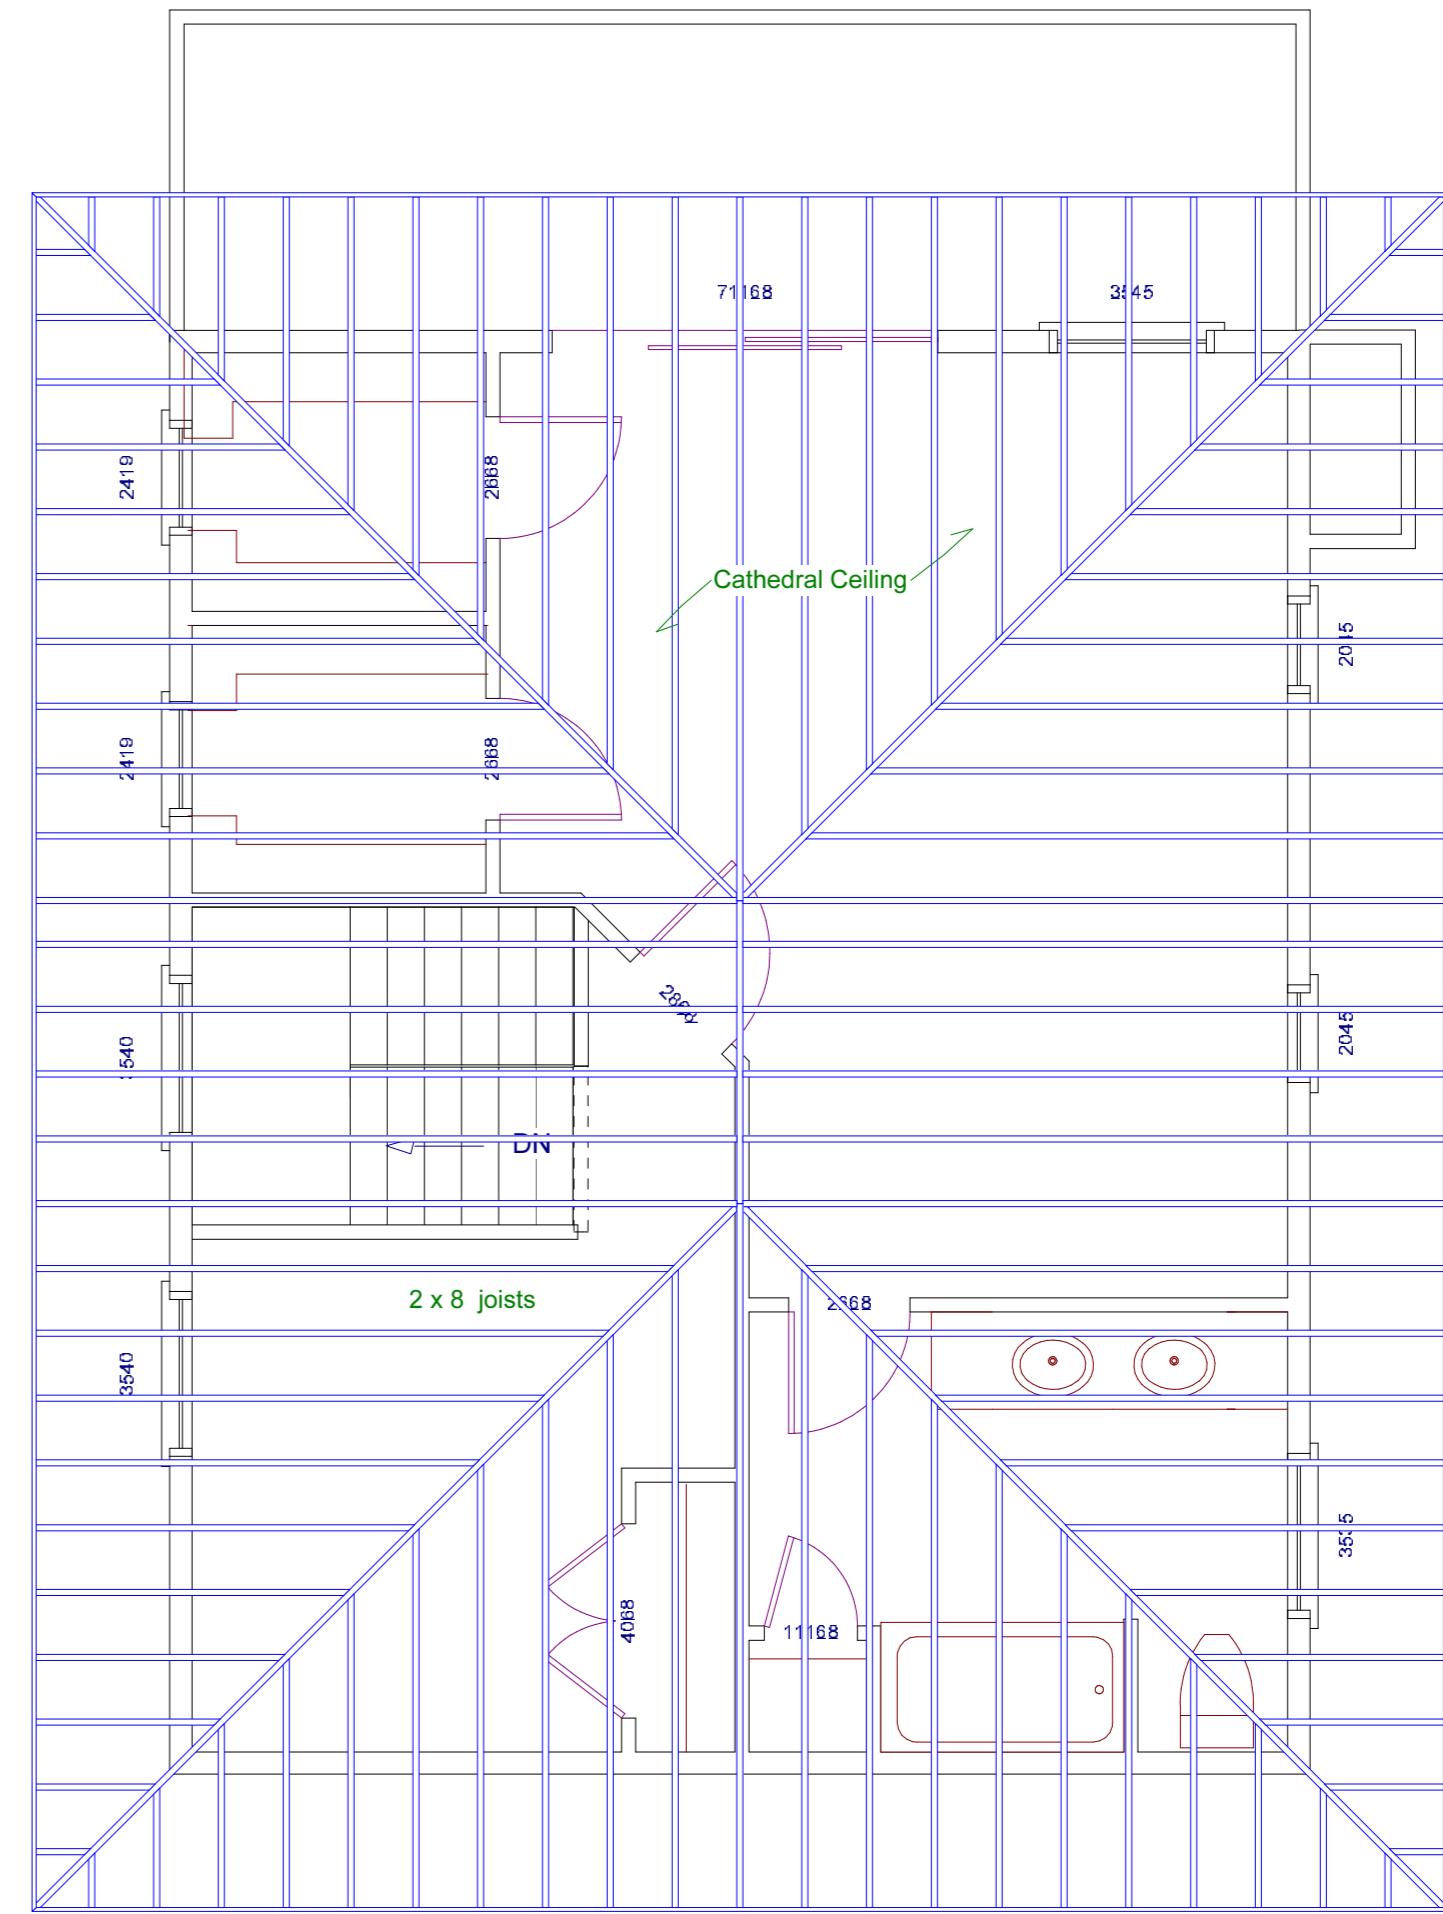

## Second Floor Roof Framing

# Ada & David Kohlus Residence

Copyright (c) 2003. All rights reserved.



Copyright (c) 2008, All rights reserved.

# David A. Webb, Inc.

Design, Drafting, Engineering,  
General Contracting

516 - 982 - 8502

<p><b>Ada &amp; David Kohlus Residence</b></p> <p>Montauk, NY</p>		<p>Revision 2.1</p>	<p>Copyright (c) 2003, All rights reserved.</p> <p><b>David A. Webb, Inc.</b></p> <p>Design, Drafting, Engineering, General Contracting</p> <p>516 - 982 - 8502</p>		
<p>Roof Framing Plans</p>	Date	Drawn by	Scale	Sheet	
	3/5/03	DW	1/8" = 1'	11	

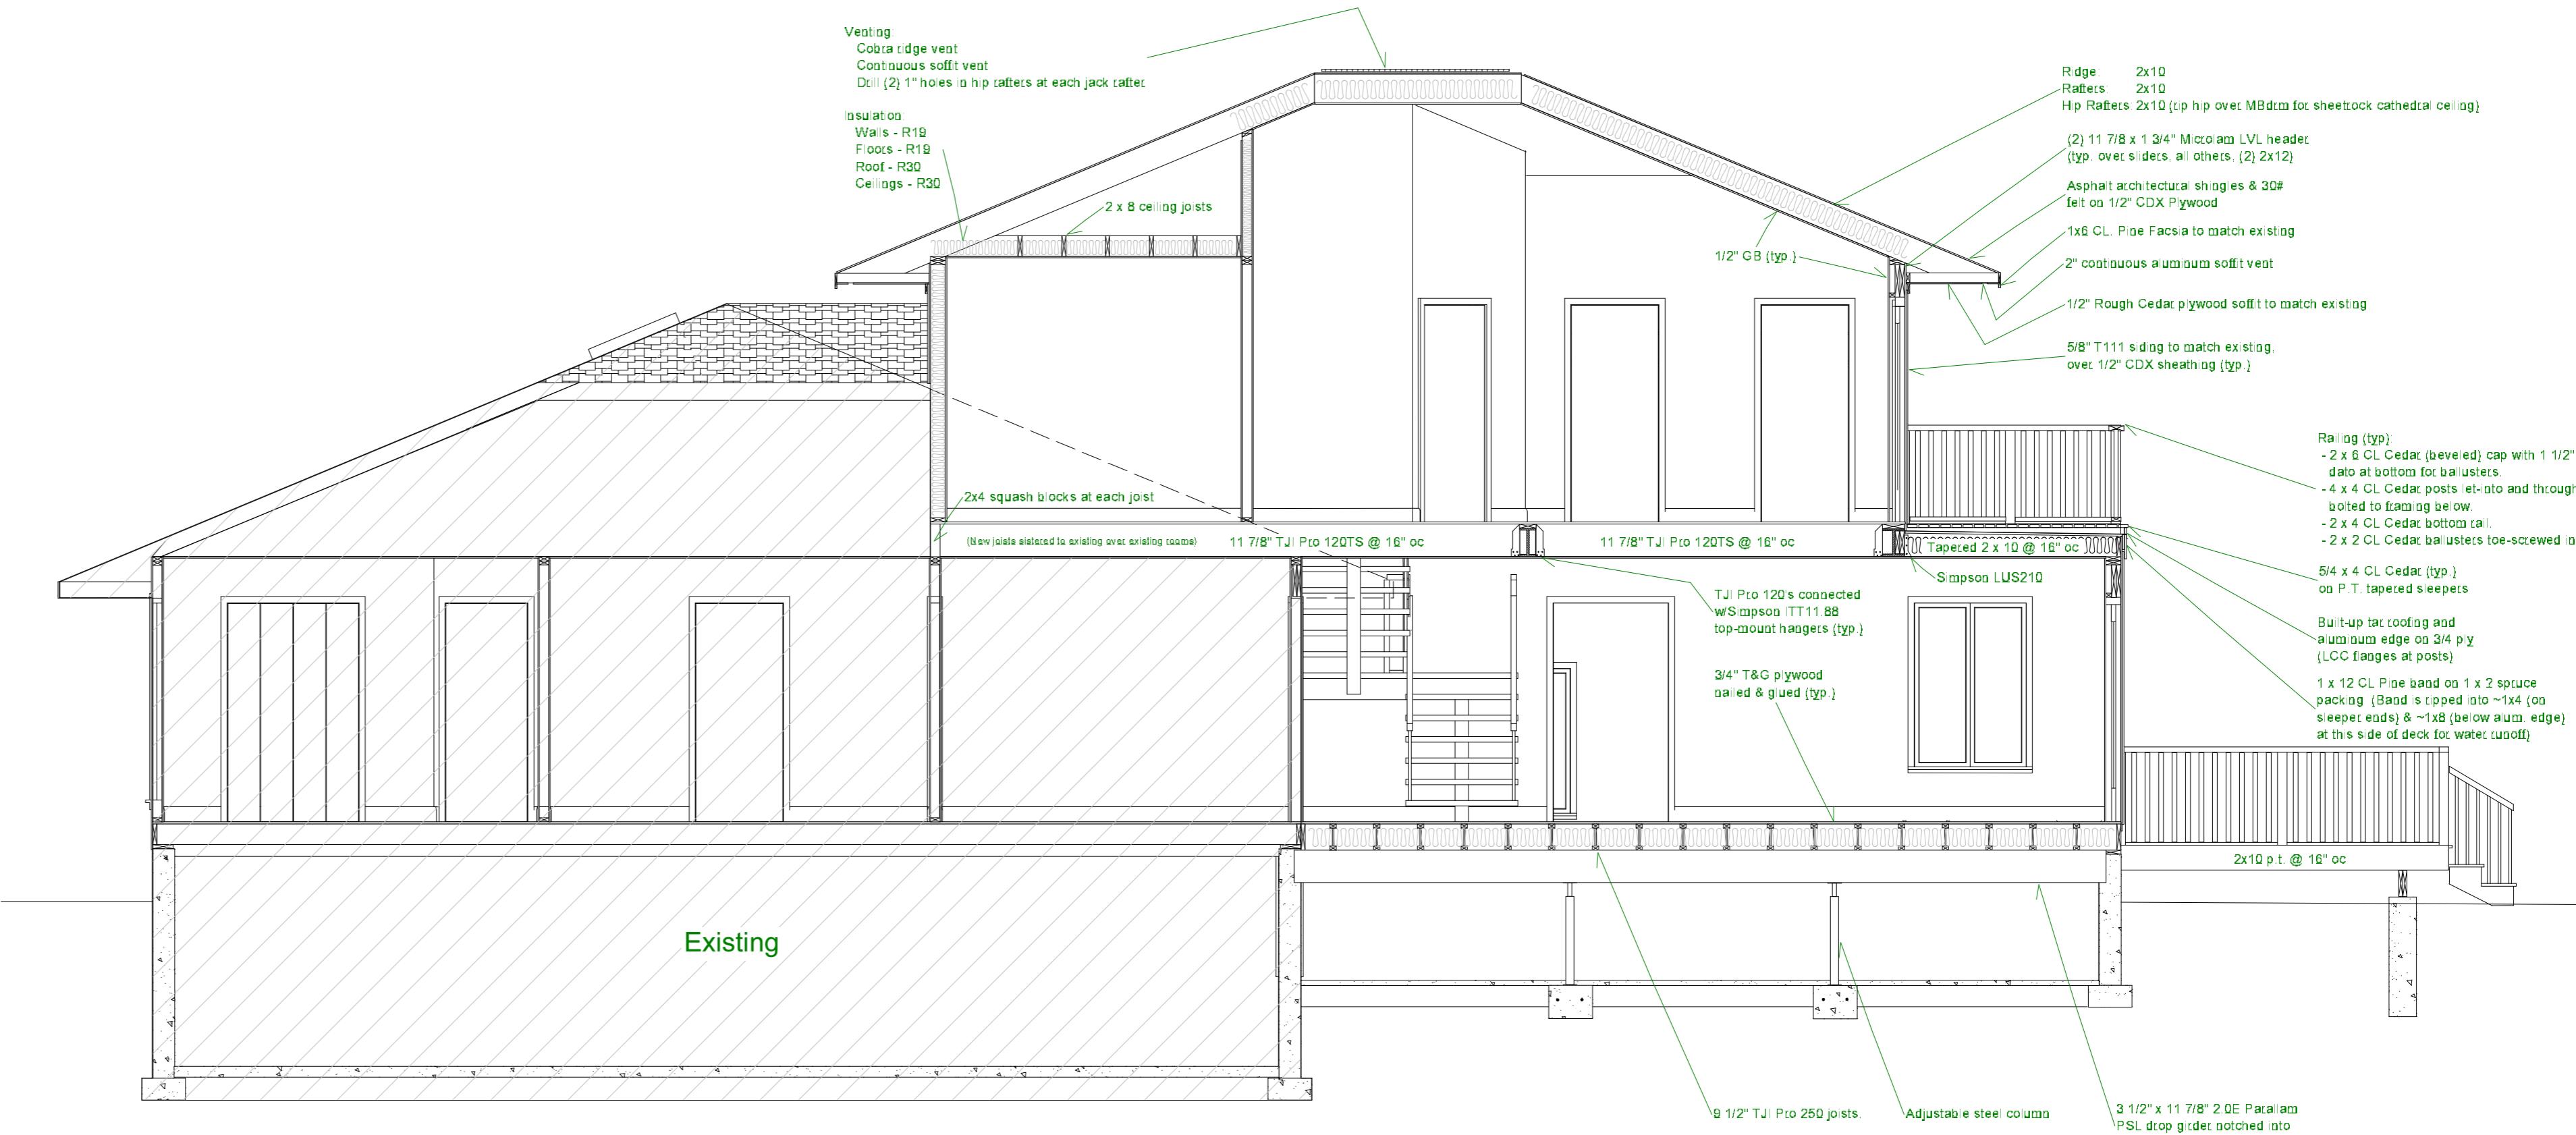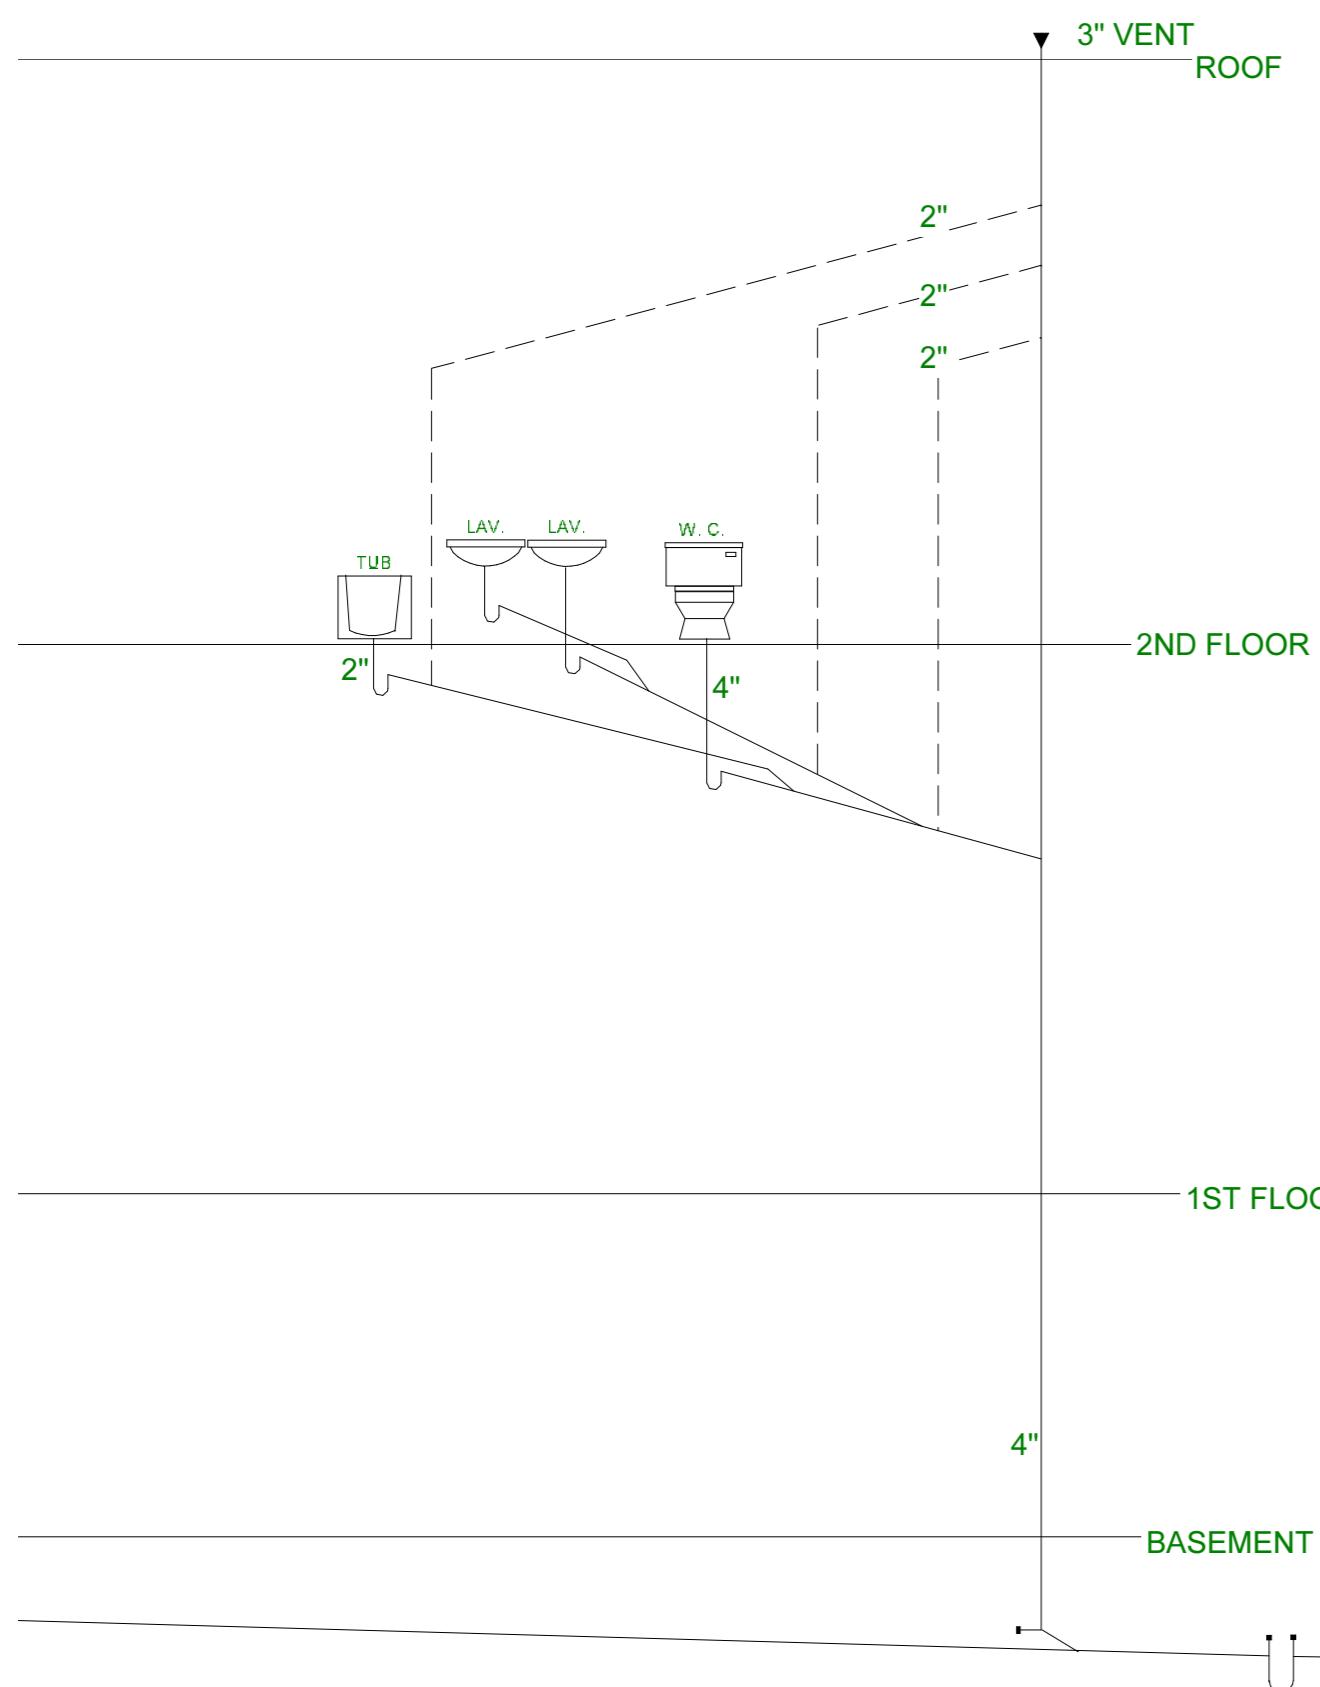

Ada & David Kohlus  
Residence  
Montauk, NY

Revision 2.1


Copyright (c) 2003. All rights reserved.  
**David A. Webb, Inc.**  
Design, Drafting, Engineering,  
General Contracting  
516 - 982 - 8502

Cross Sections

Date	Drawn by	Scale	Sheet
3/5/03	DW	1/8" = 1'	12



First Floor

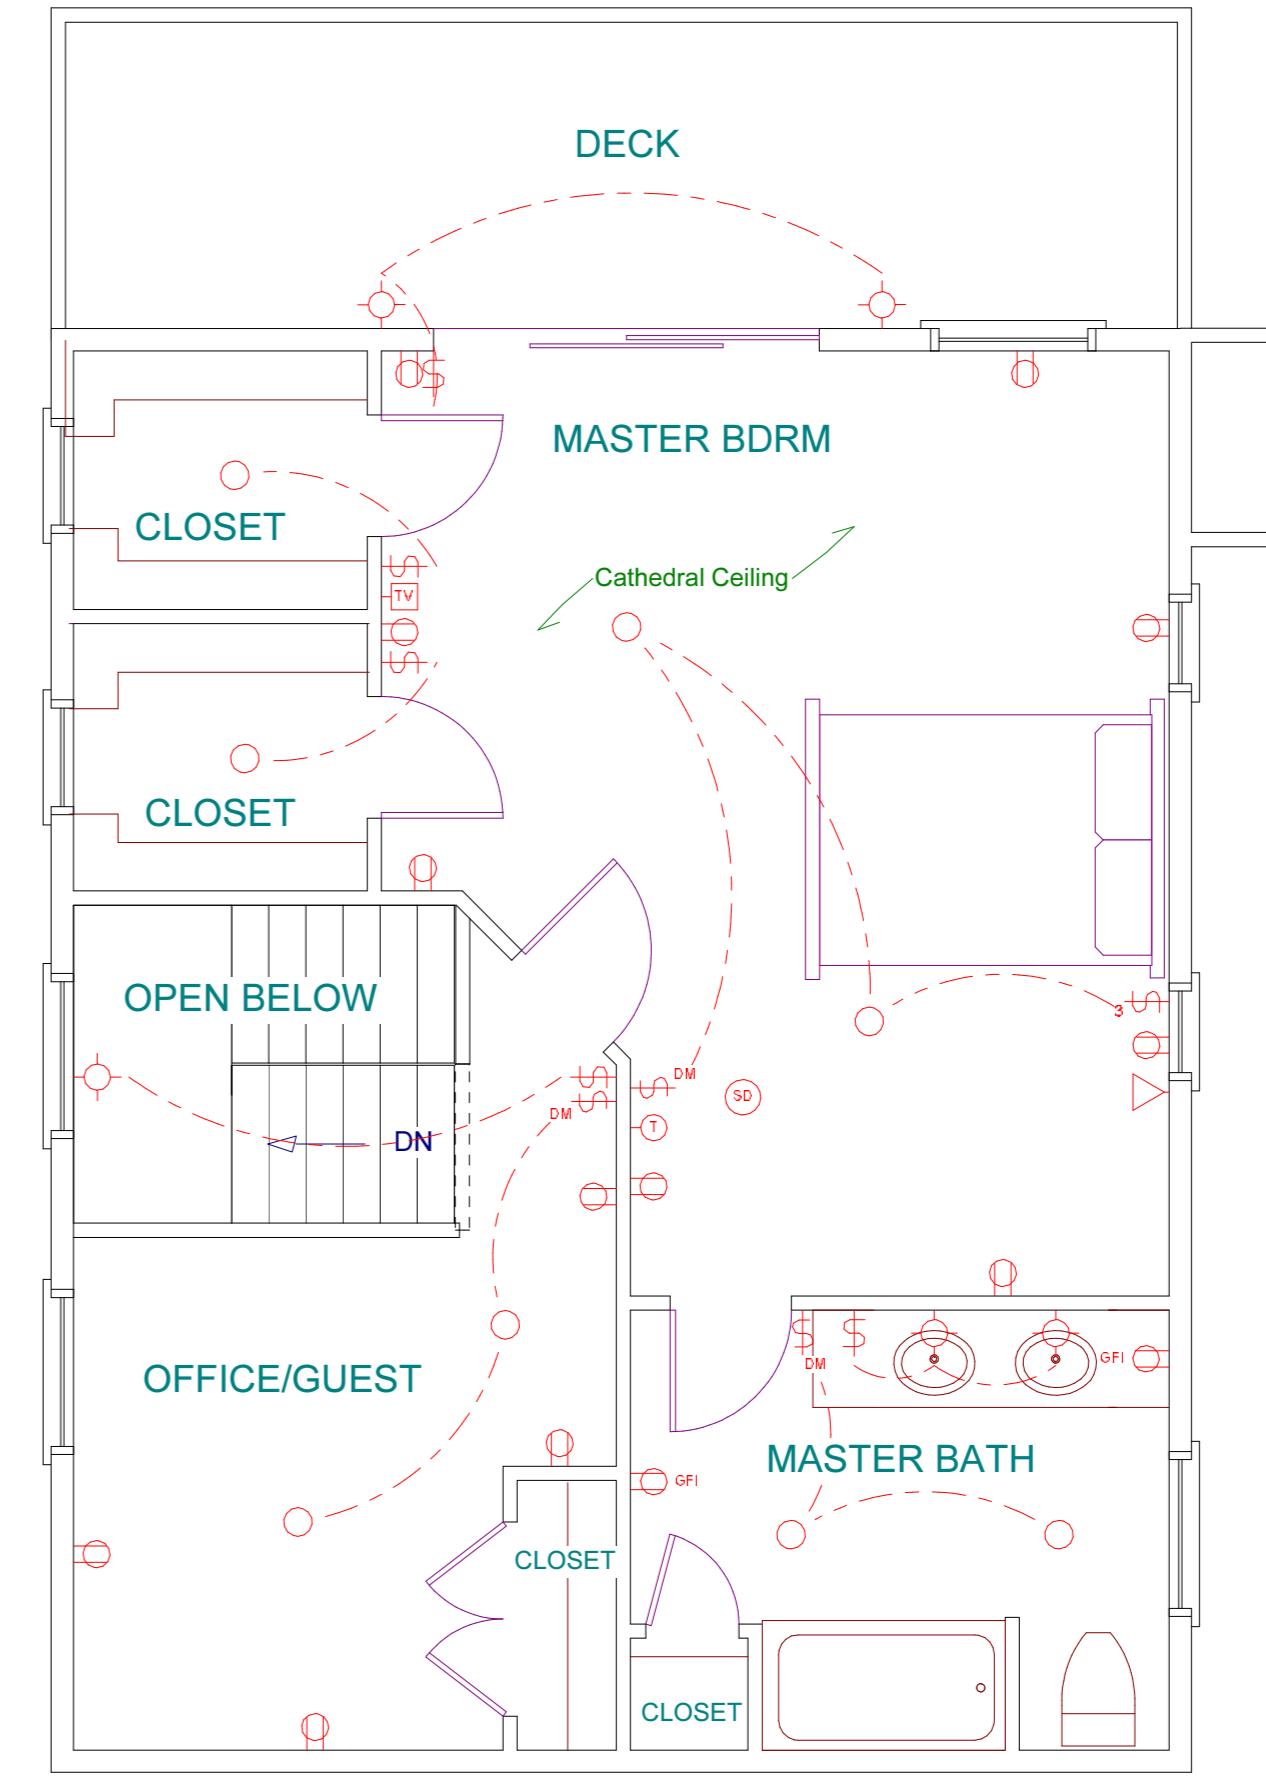

Second Floor

Ada & David Kohlus  
Residence  
Montauk, NY

Revision 2.1

Copyright (c) 2003. All rights reserved.  
**David A. Webb, Inc.**  
Design, Drafting, Engineering,  
General Contracting  
516 - 982 - 8502

Electrical

Date	Drawn by	Scale	Sheet
3/5/03	DW	1/8" = 1'	13